

SUBMISSION DRAWING-01

SITE PLAN &
AREA CALCULATION

AREA DETAILS / PRIMARY SCHOOL

TOTAL SITE AREA = 4046.856 SQM (1 acre as per zoning)
 PERMISSIBLE F.A.R @ 1.5 OF 1.0 ACRE = 6070.284 SQM
 PROPOSED F.A.R. AREA = 5438.325 SQM
 PROPOSED F.A.R. = 5438.325 / 4046.856 = 1.343 < 1.5
 PERMISSIBLE GR. COVERAGE @ 35% = 1416.399 SQM
 PROPOSED GROUND COVERAGE = 1385.957 SQM. (34.24%)

TOTAL PARKING AREA REQUIRED: 15% OF TOTAL SITE = 607.02 SQM
 TOTAL PARKING AREA PROVIDED = 608.035 SQM SQM

DETAIL AREA CALCULATION

S.NO	LENGTH X BREADTH (M)	AREA (SQM)	NO	TOTAL AREA (SQM)
1	2.03 X 7.84	15.509	1	15.509
1a	0.955 X 3.315	3.165	1	3.165
2	5.73 X 19.42	111.276	1	111.276
3	2.97 X 5.73	17.016	1	17.016
4	8.16 X 24.32	198.451	1	198.451
5	3.635 X 2.55	9.269	1	9.269
6	9.03 X 17.09	154.322	1	154.322
7	3.53 X 6.15	21.639	1	21.639
8	5.5 X 1.8	9.9	1	9.9
9	23.15 X 2.355	54.518	1	54.518
9A	3.3 X 0.59	1.948	1	1.948
10	17.22 X 17.28	298.268	1	298.268
11	17.22 X 8.13	140.558	1	140.558
12	1.985 X 0.75	1.489	2	2.978
13	3.7 X 21.82	80.734	1	80.734
13A	3.7 X 0.3	1.11	1	1.11
13B	0.2 X 0.75	0.15	1	0.15
13C	0.2 X 0.45	0.09	1	0.09
14	9.69 X 23.21	225.067	1	225.067
15	0.45 X 0.37	0.168	1	0.168
15A	0.45 X 0.56	0.252	1	0.252
16	5.170 X 0.37	1.912	1	1.912
17	0.5 X 0.37	0.185	1	0.185
18	3.82 X 0.37	0.142	1	0.142
	TOTAL AREA (A1)			1316.712

GROUND COVERAGE OF SCHOOL BUILDING
 = (A1) - (1a+9+12+16+18+D1+D2+D3+D4)
 = 1316.712 - (3.165+9.269+1.948+1.11+0.15+0.09+0.252+0.142)
 = 1316.712 - (88.323) + 4.53 = 1225.919 SQM

GROUND COVERAGE OF STAFF QUARTER = 133.038 SQM
 (REFER SEPARATE SHEET)
 TOTAL GROUND COVERAGE = 1225.919 + 133.038 = 1358.957 SQM

TOTAL F.A.R. AREA OF SCHOOL BUILDING

GROUND FLOOR AREA = GROUND COVERAGE - (13A, part of fire staircase)
 = 1225.919 - 1.11 = 1224.809 SQM

FIRST FLOOR AREA = (A1) - (8+13A+D)
 = 1316.712 - (9.9+1.11+78.231)
 = 1316.712 - 89.241 = 1227.471 SQM

SECOND FLOOR AREA = (A1) - (13A+D)
 = 1316.712 - (1.11+78.231) = 1237.371 SQM

THIRD FLOOR AREA = (A1) - (1+13A+D)
 = 1316.712 - (15.509+1.11+78.231)
 = 1316.712 - 94.85 = 1221.862 SQM

TOTAL F.A.R. AREA (A) = 1221.862 + 1227.471 + 1237.371 + 1221.862
 = 4908.565 SQM

TOTAL F.A.R. AREA OF STAFF QUARTER (C) = 499.812 SQM

(REFER SHEET NO-8 FOR DETAILS)

TOTAL ACHIEVED F.A.R. AREA
 = A+C = 4908.565 + 499.812 = 5408.377 SQM

S.NO	LENGTH X BREADTH (M)	AREA (SQM)	NO	TOTAL AREA (SQM)
19	0.4 X 0.6	0.24	8	1.92
19A	0.3 X 0.6	0.18	7	1.26
20	0.4 X 0.3	0.12	3	0.36
21	0.15 X 0.3	0.045	22	0.99
	TOTAL AREA (A2)			4.53

DESCRIPTION OF AREAS:

3. FLOOR PROJECTION AT FIRST FLOOR LEVEL
6. FLOOR PROJECTION AT SECOND FLOOR LEVEL
12. BOX PROJECTION AT FIRST FLOOR LEVEL
- 13A. FIRE STAIRCASE EXTENSION AT GROUND FLOOR LEVEL
16. FLOOR PROJECTION AT FIRST FLOOR LEVEL

S.NO	LENGTH X BREADTH (M)	AREA (SQM)	NO	TOTAL AREA (SQM)	REMARKS
D1	5.5 X 3.0	16.5	1	16.5	OPEN TO SKY COURT YARD
D2	1.5 X 3.24	4.86	1	4.86	PLUMBING SHAFT
D3	2.0 X 2.75	5.5	1	5.5	LIFT WELL
D4	3.3 X 8.9	29.37	1	29.37	STAIRWELL OF STAIRCASE 1
D5	3.7 X 7.73	28.601	1	28.601	FIRE STAIRCASE
	TOTAL AREA (D)			70.231	

BUILT UP AREA CALCULATION

I	TOTAL ACHIEVED F.A.R. AREA = 5408.377 SQM
II	TOTAL BASEMENT AREA = 408.251 SQM
III	AREA OF STAIRCASE 1 (D4): 29.37 SQM (1ST-3RD FLOOR) = 22.77 X 3 = 88.31 SQM AREA OF STAIRCASE 2 (D5): 28.601 SQM (GROUND-3RD FLOOR) = 2.8601 X 4 = 114.404 SQM TOTAL AREA = 88.31 + 114.404 = 202.714 SQM
IV	AREA OF SERVICE BALCONIES SBI: 2.705 X 1.0 = 2.705 SQM SBI2: 3.5 X 1.2 = 4.2 SQM BI: 3.3 X 1.8 = 5.94 SQM SBI3: 1.0 X 2.0 = 2.0 SQM SBI4: 1.0 X 2.275 = 2.275 SQM TOTAL AREA = 20.124 SQM
V	AREA OF STAIRCASE & MUMTY MACHINE ROOM TOTAL AREA = 83.307 SQM
	TOTAL BUILT UP AREA = I+II+III+IV+V = 5408.377+408.251+202.714+20.124+83.307 = 6122.763 SQM

LEGEND	
WATER SUPPLY LINE	
SOIL PIPE LINE	
WASTE WATER PIPE	
STORM WATER DRAIN PIPE	
WATER SUPPLY TO FIC	
WATER SUPPLY TO SPRINKLER	
BEVERAGE MANHOLE	
GULLY TRAP	
INSPECTION CHAMBER	
DRAINAGE MANHOLE	
CATCH BASIN	
FT	FLOOR TRAP
DP	DRAIN POINT

PIPE NO.	CLASSIFICATION	SIZE (Ø)
1-10	SOIL AND WASTE PIPE	150/100
11-15	WASTE AND VENT PIPE	100
16-18	RAIN WATER PIPE	150
19	CWS RISER TO CHT	50
20	CWS DROP FROM CHT	30/20
21	FIRE PIPE DROP TO FIC	50
22	FIRE SPRINKLER PIPE DROP	100


NOTE:

1. All levels are given in reference to external road level, assuming it to be 800.
2. All dimensions are in mm unless otherwise mentioned.
3. Drawings not to be scaled, written dimensions to be followed.
4. Rain water harvesting system shall be provided at site as per prevailing norms of the Government.
5. LED system shall be provided at site as per prevailing norms of the Government.
6. Proposed building shall be fully air-conditioned and mechanically ventilated with 100% power backup.
7. Solar assisted water heating system will be provided as per norms.

PROJECT TITLE

REVISED BUILDING PLAN OF PRIMARY SCHOOL
 SITE (PS-3) MEASURING 1.00 ACRE FALLING IN
 RESIDENTIAL PLOTTED COLONY MEASURING
 365.396 ACRES (LICENCE NO.1134 TO
 1166 OF 2006 DATED 22.09.2006, LICENCE NO.187
 OF 2008 DATED 08.11.2008 AND
 LICENCE NO.17 OF 2009 DATED 31.5.2009) IN
 SECTOR 34 (PART), 35 & 36, ROHTAK
 BEING DEVELOPED BY SHARAD FARMS AND
 HOLDINGS PVT. LTD. AND OTHERS.
 GARGI FARMS

LOCATION SECTOR 35, ROHTAK, HARYANA

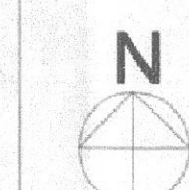

FIRE DRAWING

DRAWING TITLE SITE PLAN & AREA CALCULATION

DRAWING NO

DATE: FEB 2017 SCALE:

DRAWN:

CHECKED:

OWNER

ARCHITECTS & PLANNERS




wrtA Design Studio

D-603, Aditya Celebrity Homes
 Sector-76, Noida (UP)
 e-mail: wrtdesigns@gmail.com


Fire Fighting Scheme Approval
 Vide letter No. SF/2019/38
 Dated 27/5/19

27/5/19



Ranjan Mohanty
 Architect
 CA/2002/30498

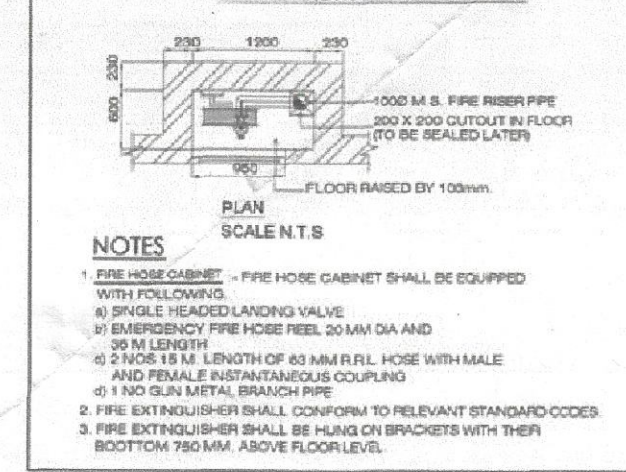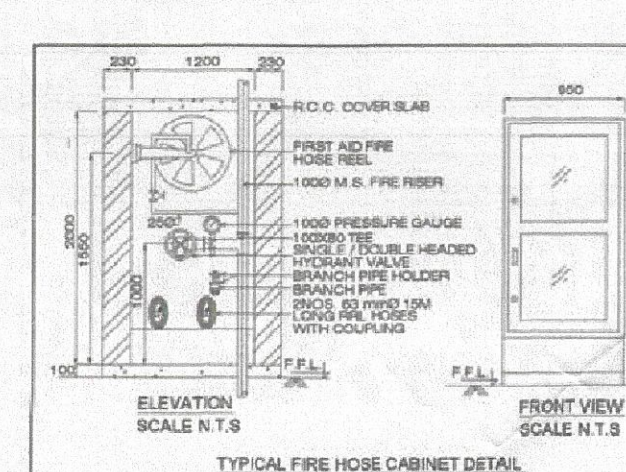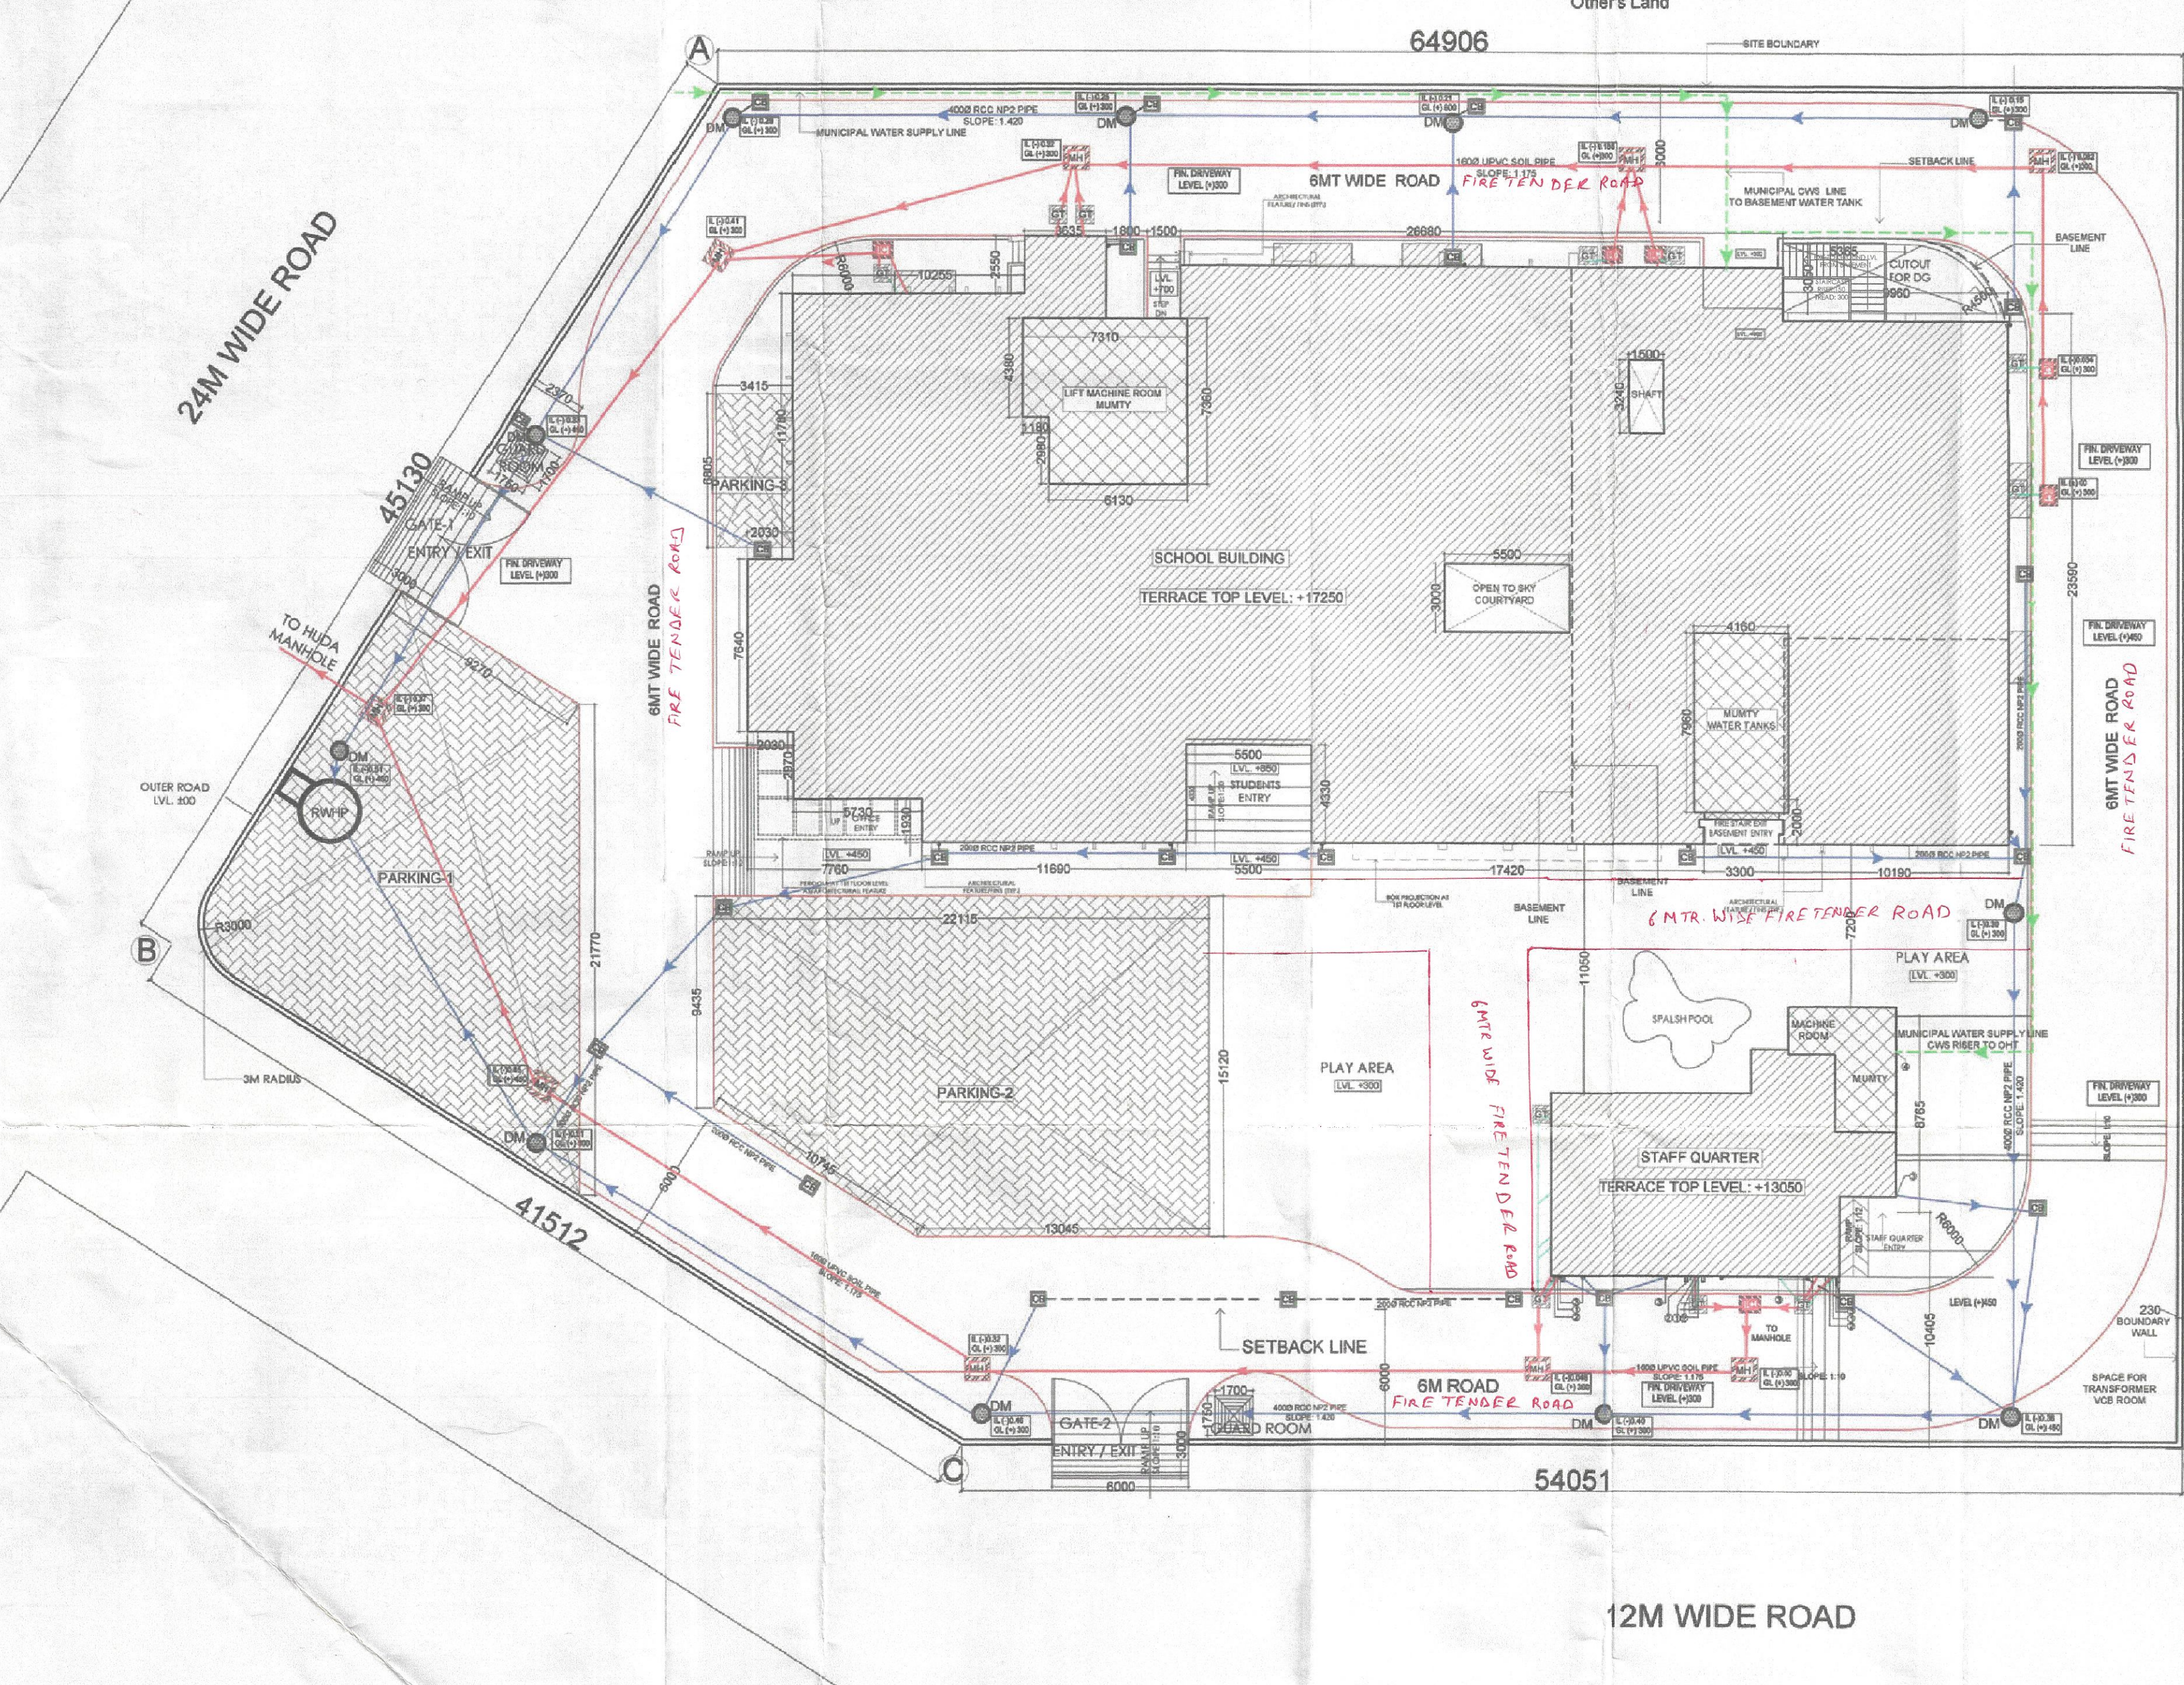PARKING
AREA DIAGRAMS

S.NO	LENGTH X BREADTH (M)	AREA (SQM)	NO	TOTAL AREA (SQM)
P1	2.77 X 15.805	43.225	1	43.225
P2	1/2 X 3.141 X 2.77 X 2.77	6.025	1	6.025
P3	6.5 X 18.375	119.437	1	119.437
P4	1/2 X 11.87 X 18.375	107.218	1	107.218
P5	9.07 X 9.43	85.53	1	85.53
P6	13.045 X 15.12	197.24	1	197.24
P7	1/2 X 5.76 X 9.07	26.121	1	26.121
P8	3.415 X 8.805	23.239	1	23.239
	TOTAL AREA			608.035 SQM

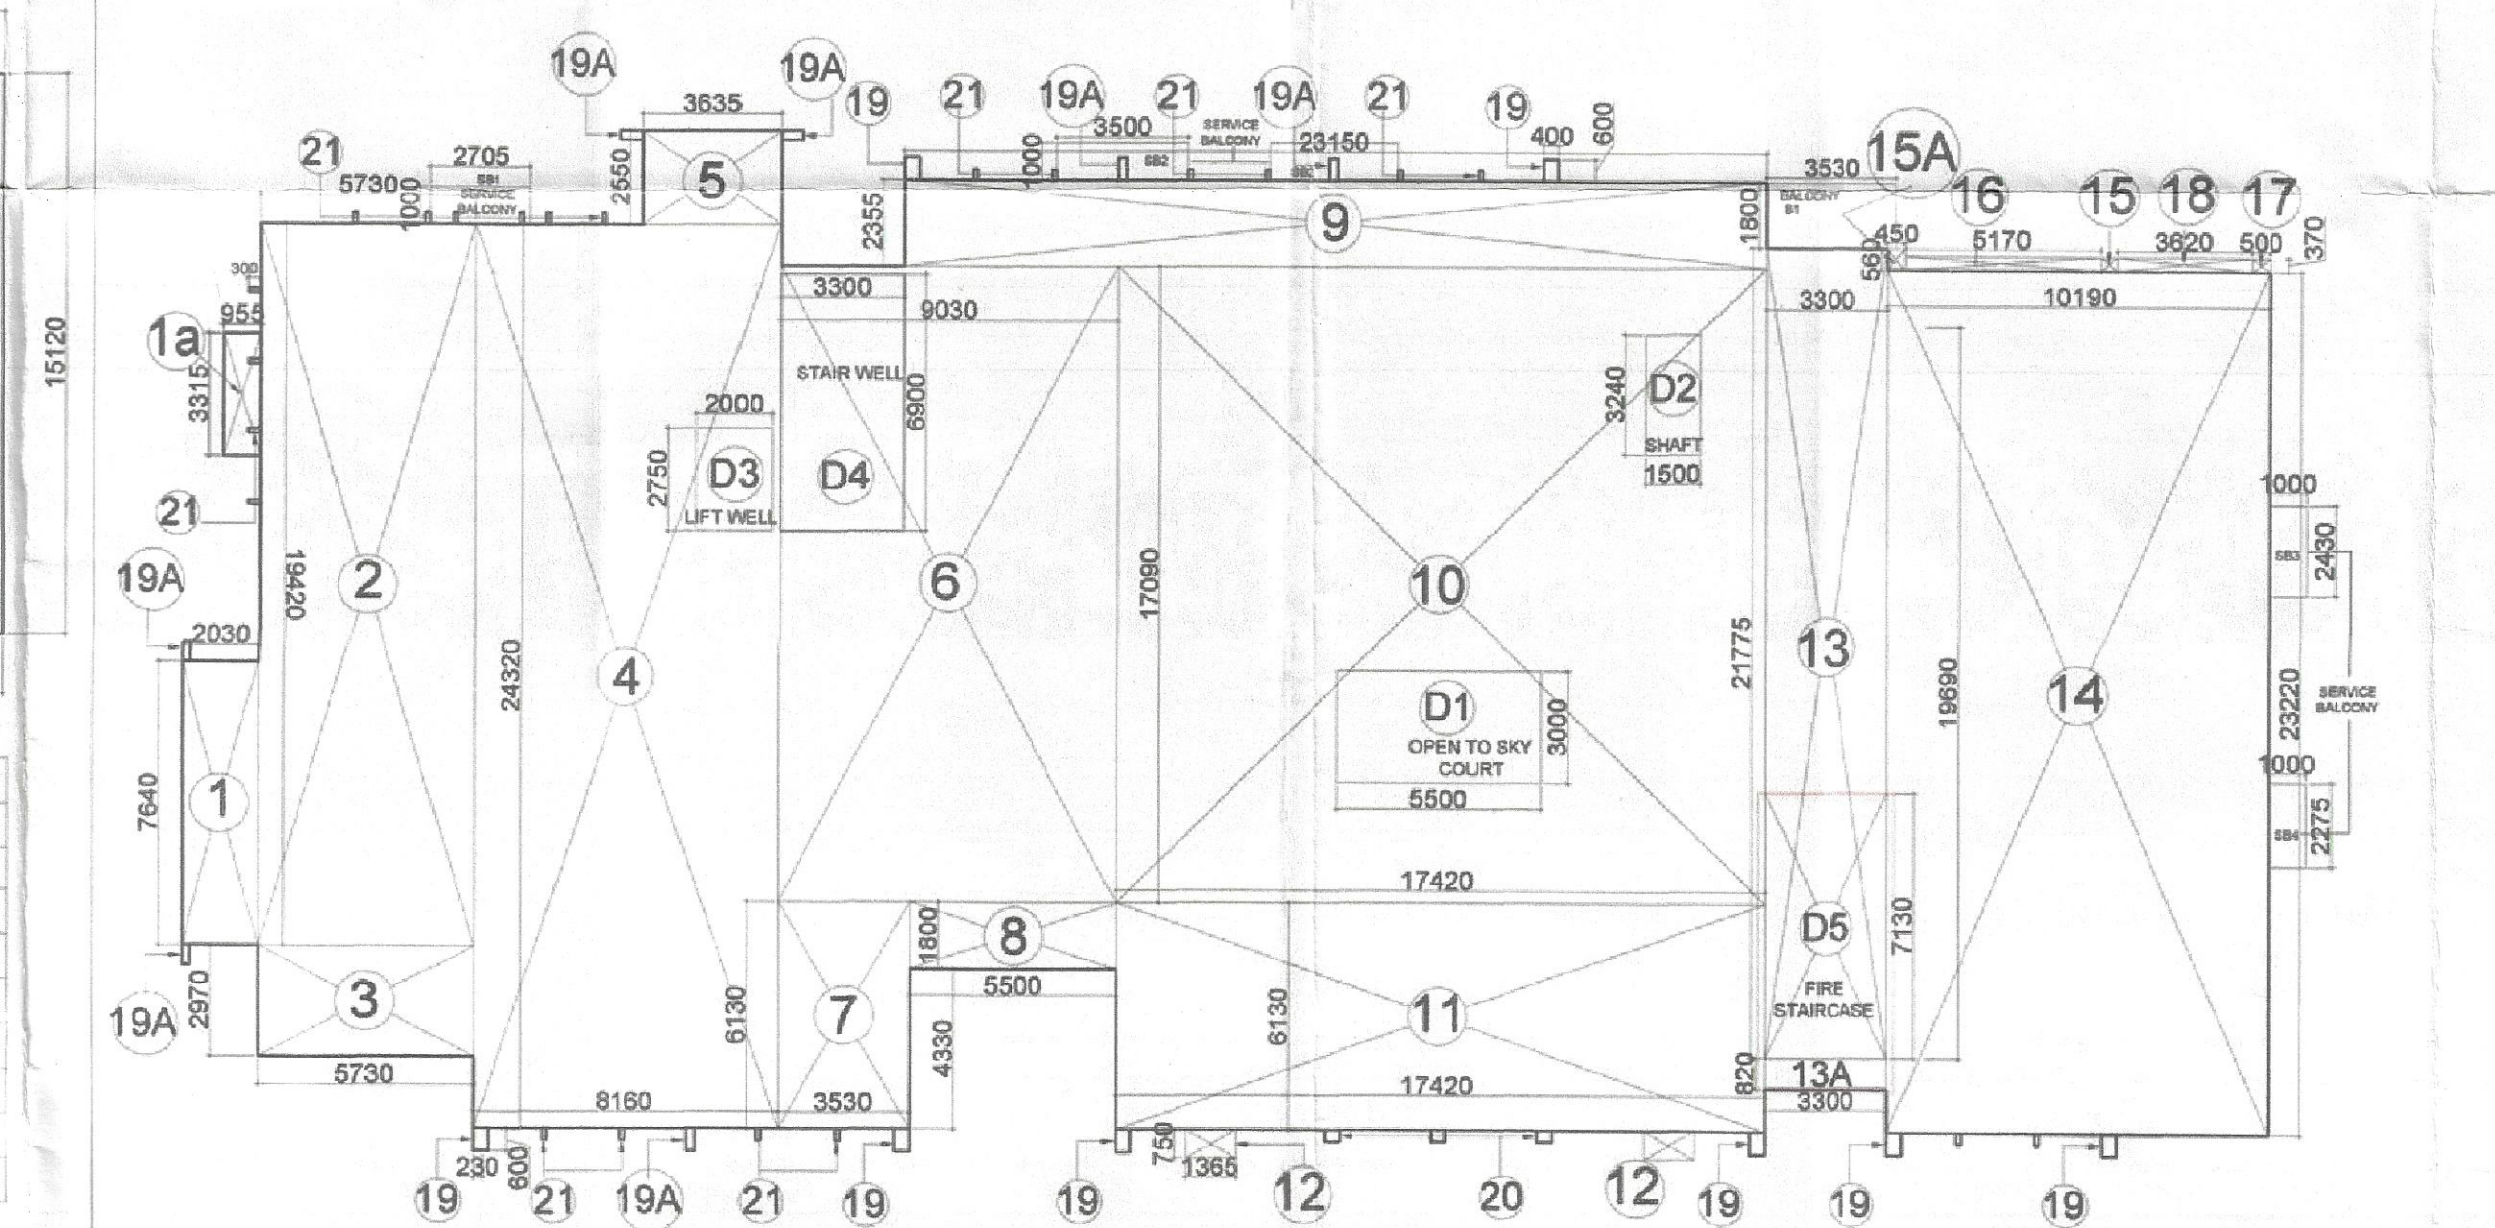

FLOOR AREA DIAGRAM

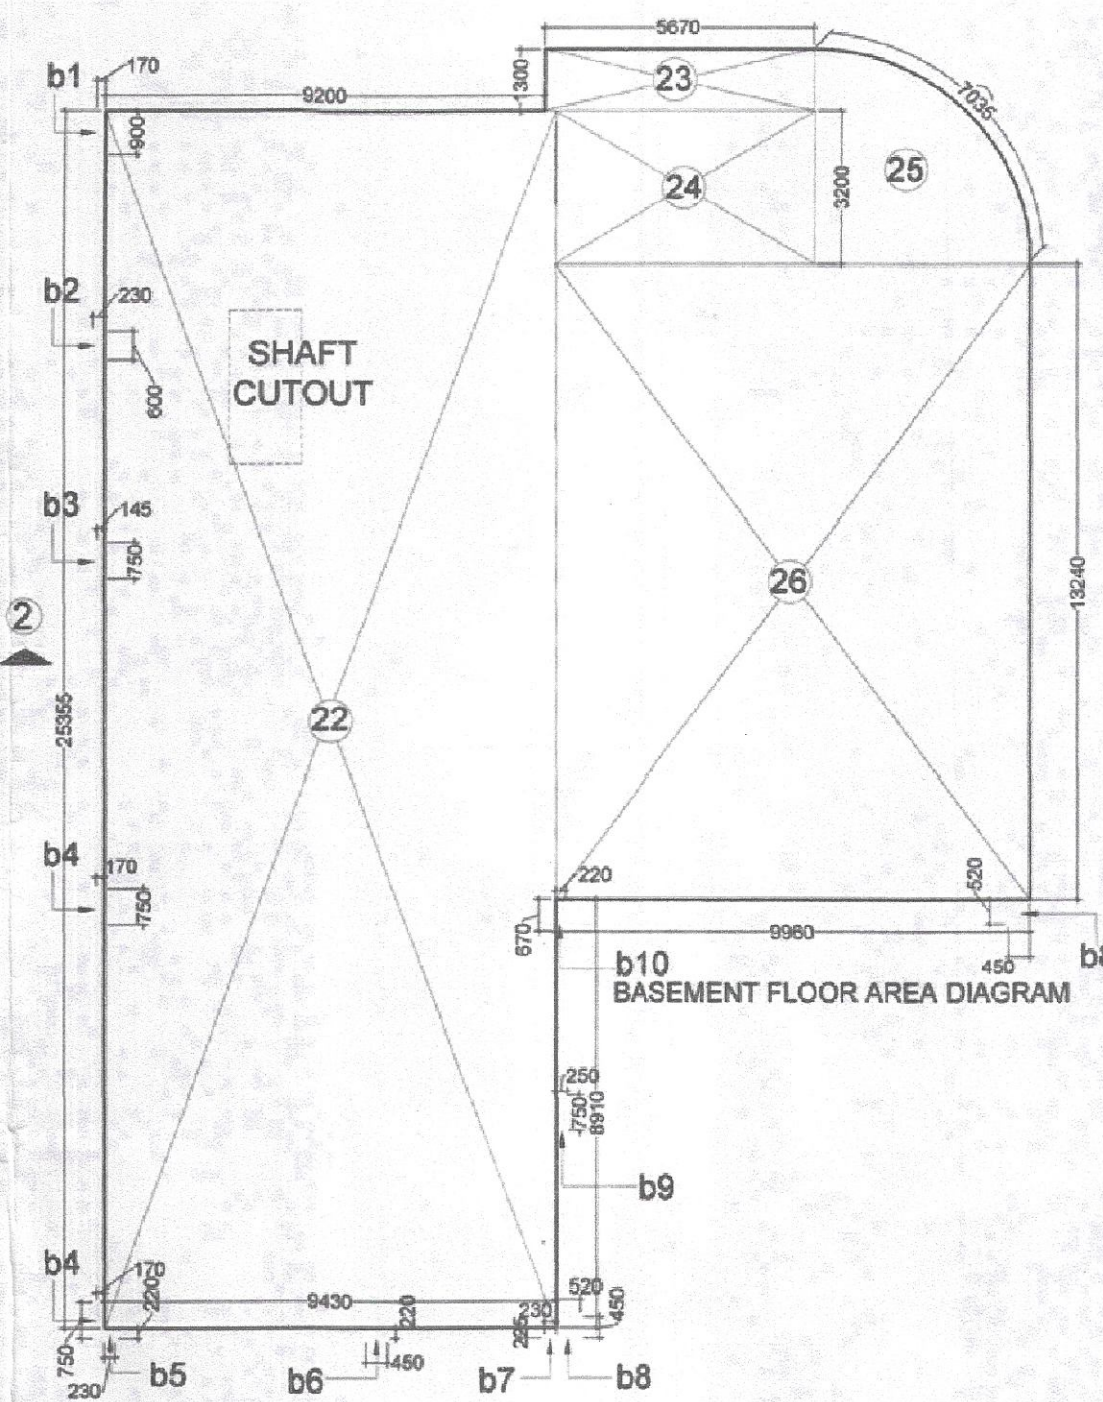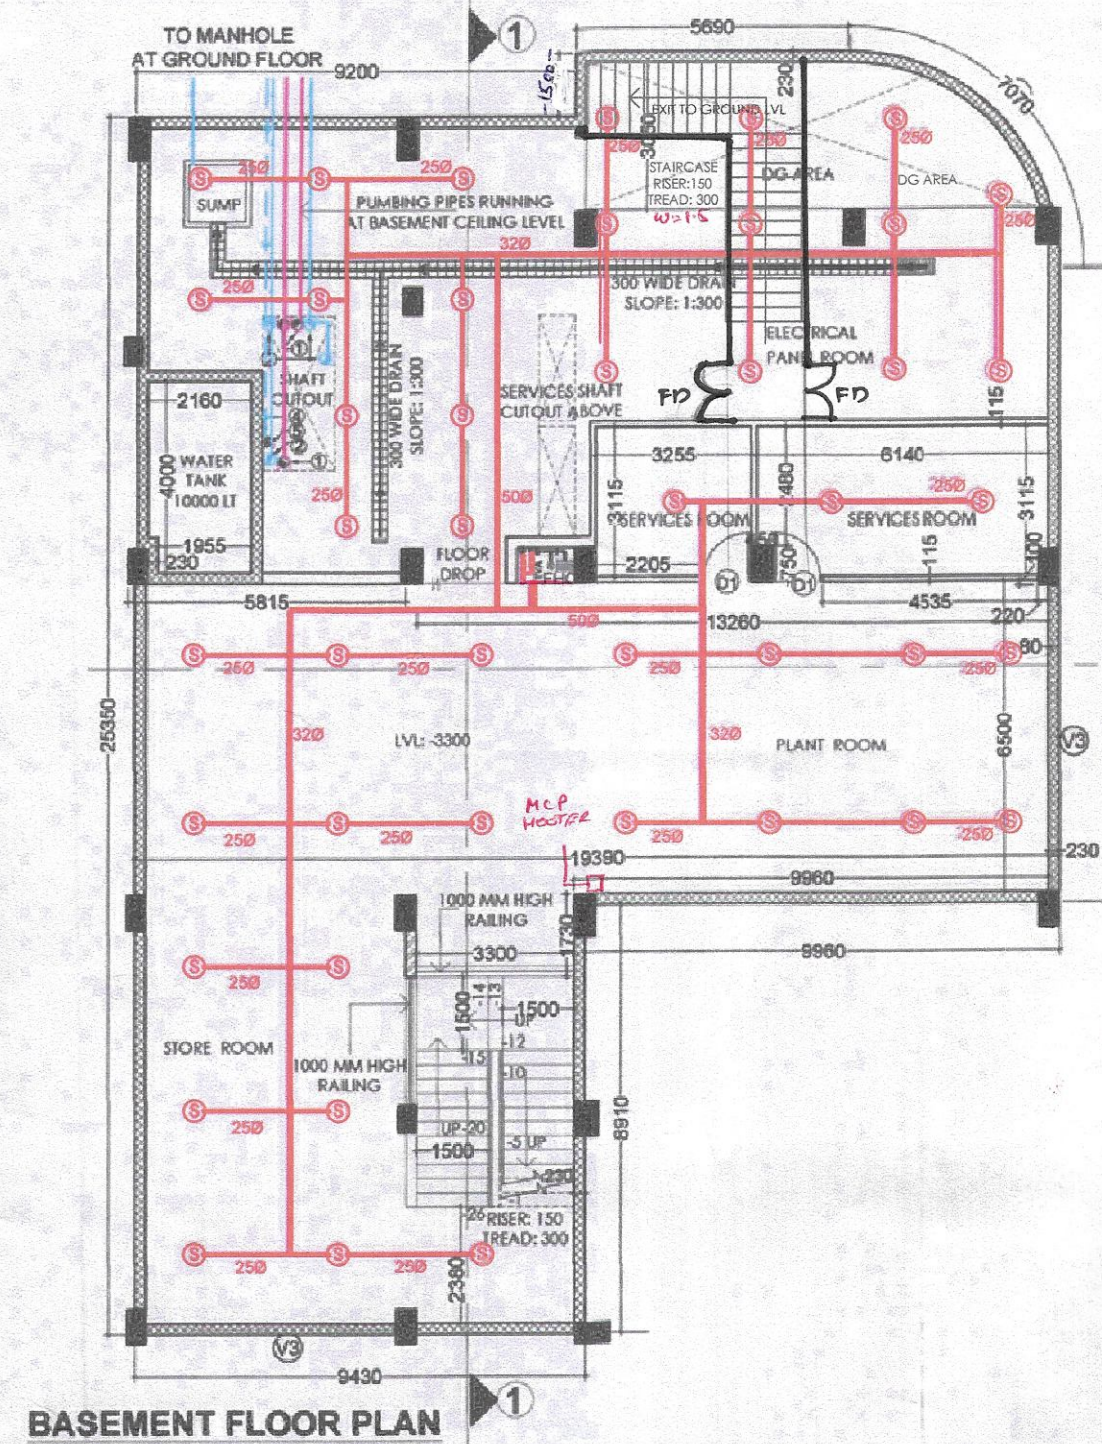

BASEMENT FLOOR AREA CALCULATION			
S.NO	LENGTH X BREADTH (M)	AREA (SQM)	NO
22	9.2 X 25.35	233.22	1
23	5.69 X 1.3	7.397	1
24	5.69 X 3.2	18.208	1
25	1 x 3.141 x 4.5 x 4.5	15.901	1
26	9.96 X 13.24	131.87	1
TOTAL AREA		406.596	

AREA OF OUTER COLUMN PROJECTIONS
 b1: 0.17 x 0.9 = 0.153 sqm
 b2: 0.23 x 0.6 = 0.138 sqm
 b3: 0.145 x 0.75 = 0.109 sqm
 b4: 0.17 x 0.75 x 2 = 0.255 sqm
 b5: 0.22 x 0.23 = 0.05 sqm
 b6: 0.22 x 0.45 = 0.099 sqm
 b7: 0.22 x 0.23 = 0.05 sqm
 b8: 0.52 x 0.45 x 2 = 0.468 sqm
 b9: 0.25 x 0.75 = 0.187 sqm
 b10: 0.22 x 0.67 = 0.147 sqm
 Total Column projection area: 1.655 sqm

TOTAL AREA OF BASEMENT (B) = 406.596 + 1.655 = 408.251 SQM

SUBMISSION DRAWING-02

BASEMENT & GROUND FLOOR PLAN

LEGEND	
(Symbol)	ROHTAK
(Symbol)	WATER SUPPLY LINE (number)
(Symbol)	SOIL PIPE LINE
(Symbol)	WASTE WATER PIPE
(Symbol)	STORM WATER DRAIN PIPE
(Symbol)	WATER SUPPLY TO FHC
(Symbol)	WATER SUPPLY TO SPRINKLER
(Symbol)	SEWERAGE MANHOLE
(Symbol)	GULLY TRAP
(Symbol)	INSPECTION CHAMBER
(Symbol)	DRAINAGE MANHOLE
(Symbol)	CATCH BASIN
(Symbol)	FLOOR TRAP
(Symbol)	DRAIN POINT

PIPE SCHEDULE

PIPE NO.	CLASSIFICATION	SIZE (Ø)
1	SOIL AND VENT PIPE	150/100
2	WASTE AND VENT PIPE	100
3	RAIN WATER PIPE	150
4	CWS RISER TO OHT	32
5	CWS DROP FROM OHT	32/20
6	FIRE PIPE DROP TO FHC	50
7	FIRE SPRINKLER PIPE DROP	100

AS PER WATER SUPPLY DISTRIBUTION DIAGRAM.

PROJECT TITLE
 REVISED BUILDING PLAN OF PRIMARY SCHOOL SITE (PS-3) MEASURING 1.00 ACRE FALLING IN RESIDENTIAL PLOTTED COLONY MEASURING 365.396 ACRES (LICENCE NO. 1134 TO 1166 OF 2006 DATED 22.09.2006, LICENCE NO. 17 OF 2008 DATED 06.11.2008 AND LICENCE NO. 17 OF 2009 DATED 31.5.2009) IN SECTOR 34 (PART) 35 & 36, ROHTAK BEING DEVELOPED BY SHARAD FARMS AND HOLDINGS PVT. LTD. AND OTHERS.

LOCATION SECTOR 35, ROHTAK, HARYANA

FIRE DRAWING

DRAWING TITLE FLOOR PLANS

DRAWING NO.

DATE: FEB 2017 SCALE: 1:100

DRAWN:

CHECKED:

OWNER

For Shared Farms & Holdings Pvt. Ltd.

Auth. Sign./Director

ARCHITECTS & PLANNERS

wrtA Design Studio

Hoida (UP)

e-mail: wrtdesign@gmail.com


Ranjan Mohanty

CA/2002/30498

Ranjan Mohanty

Architect

CA/2002/30498

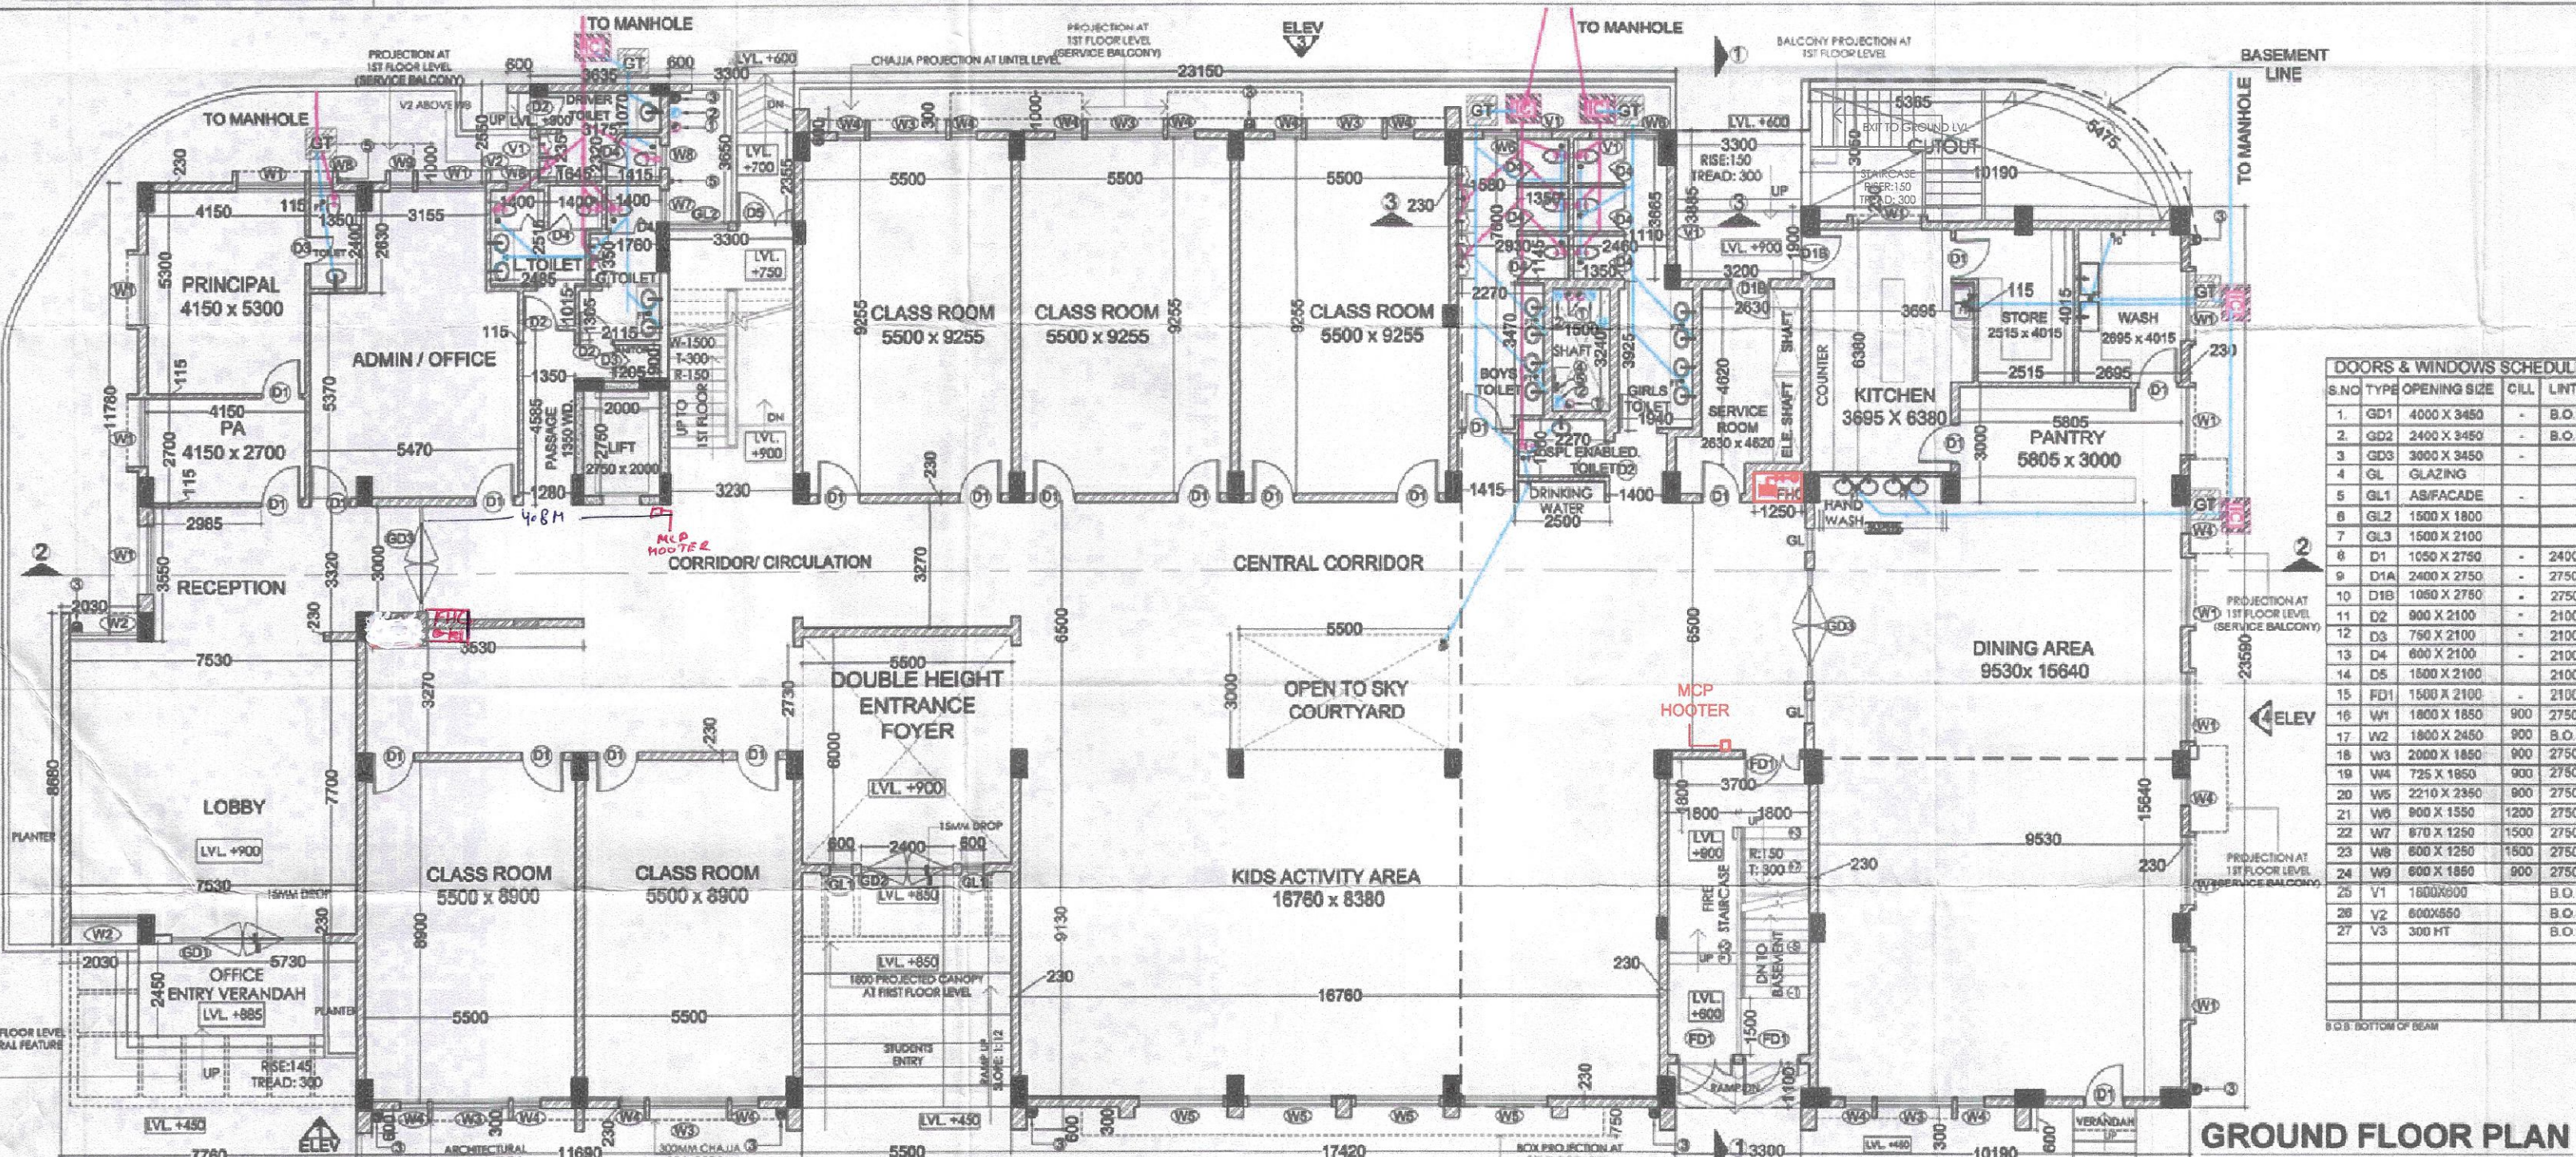

S.NO	TYPE	OPENING SIZE	GILL	LINTEL	REMARKS
1	GD1	4000 X 3450	-	B.O.B	glazing-door (2400mm)
2	GD2	2400 X 3450	-	B.O.B	glazing-door (2400mm)
3	GD3	3900 X 3450	-	B.O.B	glazing-door (2400mm)
4	GL	GLAZING	-	-	facade glazing
5	GL1	1800 X 1800	-	-	staircase glazing
6	GL2	1800 X 1800	-	-	staircase glazing
7	GL3	1500 X 2100	-	-	staircase glazing
8	D1	1050 X 2750	-	2400	
9	D1A	2400 X 2750	-	2750	
10	D1B	1050 X 2750	-	2750	
11	D2	900 X 2100	-	2100	
12	D3	750 X 2100	-	2100	
13	D4	600 X 2100	-	2100	
14	D5	1800 X 2100	-	2100	
15	FD1	1500 X 2100	-	2100	
16	W1	1800 X 1850	900	2750	
17	W2	1800 X 2450	900	B.O.B	
18	W3	2300 X 1850	900	2750	
19	W4	725 X 1850	900	2750	
20	W5	2210 X 2350	900	2750	
21	W6	800 X 1550	1200	2750	
22	W7	870 X 1250	1500	2750	
23	W8	680 X 1250	1500	2750	
24	W9	680 X 1850	900	2750	
25	V1	1800X2000	B.O.B		
26	V2	600X850	B.O.B		
27	V3	300 HT	B.O.B		BASEMENT VENT

Fire Fighting Scheme Approval

Vide letter No. SF/2019/38

Date: 27/2/19

APL

SUBMISSION DRAWING-03

FIRST & SECOND FLOOR PLAN

S.T.P.
ROHTAK
(Chairman)

S.E. HUDA
(Member)

D.T.P.
(Member)

Issued vide S.T.P. (C) Memo No.
BP-1877 dated 24/09/19

Fire Fighting Scheme Approved
Vide letter No. SP-2219/38
Dated 27/11/19

NOTE:
1. All levels are given in reference to external road level, assuming it to be 100.
2. All dimensions are in mm unless otherwise mentioned.
3. Drawings are to be scaled, within dimensions to be followed.
4. All water supply system shall be provided of the as per prevailing norms of the Government.
5. All system shall be provided of the as per prevailing norms of the Government.
6. Proposed building shall be fully air conditioned and mechanically ventilated with 100% power ventilation.
7. Solar water heating system will be provided as per norms.

PROJECT TITLE
REVISED BUILDING PLAN OF PRIMARY SCHOOL
SITE (PS-3) MEASURING 1.00 ACRE FALLING IN
RESIDENTIAL PLOTTED COLONY MEASURING
365.394 ACRES (LICENCE NO.1134 TO
1166 OF 2006 DATED 22.09.2006, LICENCE NO.187
OF 2008 DATED 08.11.2008 AND
LICENCE NO.17 OF 2009 DATED 31.5.2009) IN
SECTOR 34 (PART) 35 & 36, ROHTAK
BEING DEVELOPED BY SHARAD FARMS AND
HOLDINGS PVT. LTD. AND OTHERS

LOCATION SECTOR 35, ROHTAK, HARYANA

N
FIRE DRAWING

DRAWING TITLE FLOOR PLANS

DRAWING NO.

DATE: FEB 2017 SCALE: 1:100

DRAWN:

CHECKED:

OWNER

For Sharad Farms & Holdings Pvt. Ltd.

Auth: Sign / Director

ARCHITECTS & PLANNERS

wrtA Design Studio
Noida (UP)
e mail: wrtadesigns@gmail.com

Ranjan Mahanty
CA2002/30498

Ranjan Kumar Mahanty
Architect
CA/2002/30498

LEGEND

---	WATER SUPPLY LINE
---	SOIL PIPE LINE
---	WASTE WATER PIPE
---	STORM WATER DRAIN PIPE
---	WATER SUPPLY TO FHC
---	WATER SUPPLY TO SPRINKLER
---	SEWERAGE MANHOLE
---	GULLY TRAP
---	INSPECTION CHAMBER
---	DRAINAGE MANHOLE
---	CATCH BASIN
---	FT FLOOR TRAP
---	DP DRAIN POINT

PIPE SCHEDULE



PIPE NO.	CLASSIFICATION	SIZE (Ø)
1	SOIL AND VENT PIPE	160/100
2	WASTE AND VENT PIPE	100
3	RAIN WATER PIPE	150
4	CWS RISER TO OHT	32
5	CWS DROP FROM OHT	32/20
6	FIRE PIPE DROP TO FHC	50
7	FIRE SPRINKLER PIPE DROP	100

AS PER WATER SUPPLY DISTRIBUTION DIAGRAM.


DOORS & WINDOWS SCHEDULE

S.NO	TYPE	OPENING SIZE	CILL	LINTEL	REMARKS
1	GD1	4000 X 3450	-	B.O.B	glazing+door (2400mm)
2	GD2	2400 X 3450	-	B.O.B	glazing+door (2400mm)
3	GD3	3000 X 3450	-	-	glazing+door (2400mm)
4	GL	GLAZING	-	-	-
5	GL1	GLAZING	-	-	facade glazing
6	GL2	1500 X 1800	-	-	staircase glazing
7	GL3	1600 X 2100	-	-	staircase glazing
8	D1	1050 X 2750	-	2400	-
9	D1A	2400 X 2750	-	2750	-
10	D1B	1050 X 2750	-	2750	-
11	D2	600 X 2100	-	2100	-
12	D3	900 X 2100	-	2100	-
13	D4	600 X 2100	-	2100	-
14	D5	1500 X 2100	-	2100	-
15	FD1	1500 X 2100	-	2100	-
16	W1	1800 X 1850	600	2750	-
17	W2	1800 X 2450	900	B.O.B	-
18	W3	2000 X 1850	900	2750	-
19	W4	725 X 1850	900	2750	-
20	W5	2210 X 2350	900	2750	-
21	W6	600 X 1650	1200	2750	-
22	W7	870 X 1250	1500	2750	-
23	W8	600 X 1850	1500	2750	-
24	W9	600 X 1850	900	2750	-
25	V1	1800X900	-	B.O.B	-
26	V2	600X550	-	B.O.B	-
27	VS	500 HT	-	B.O.B	BASEMENT VENT

B.O.B: BOTTOM OF BEAM

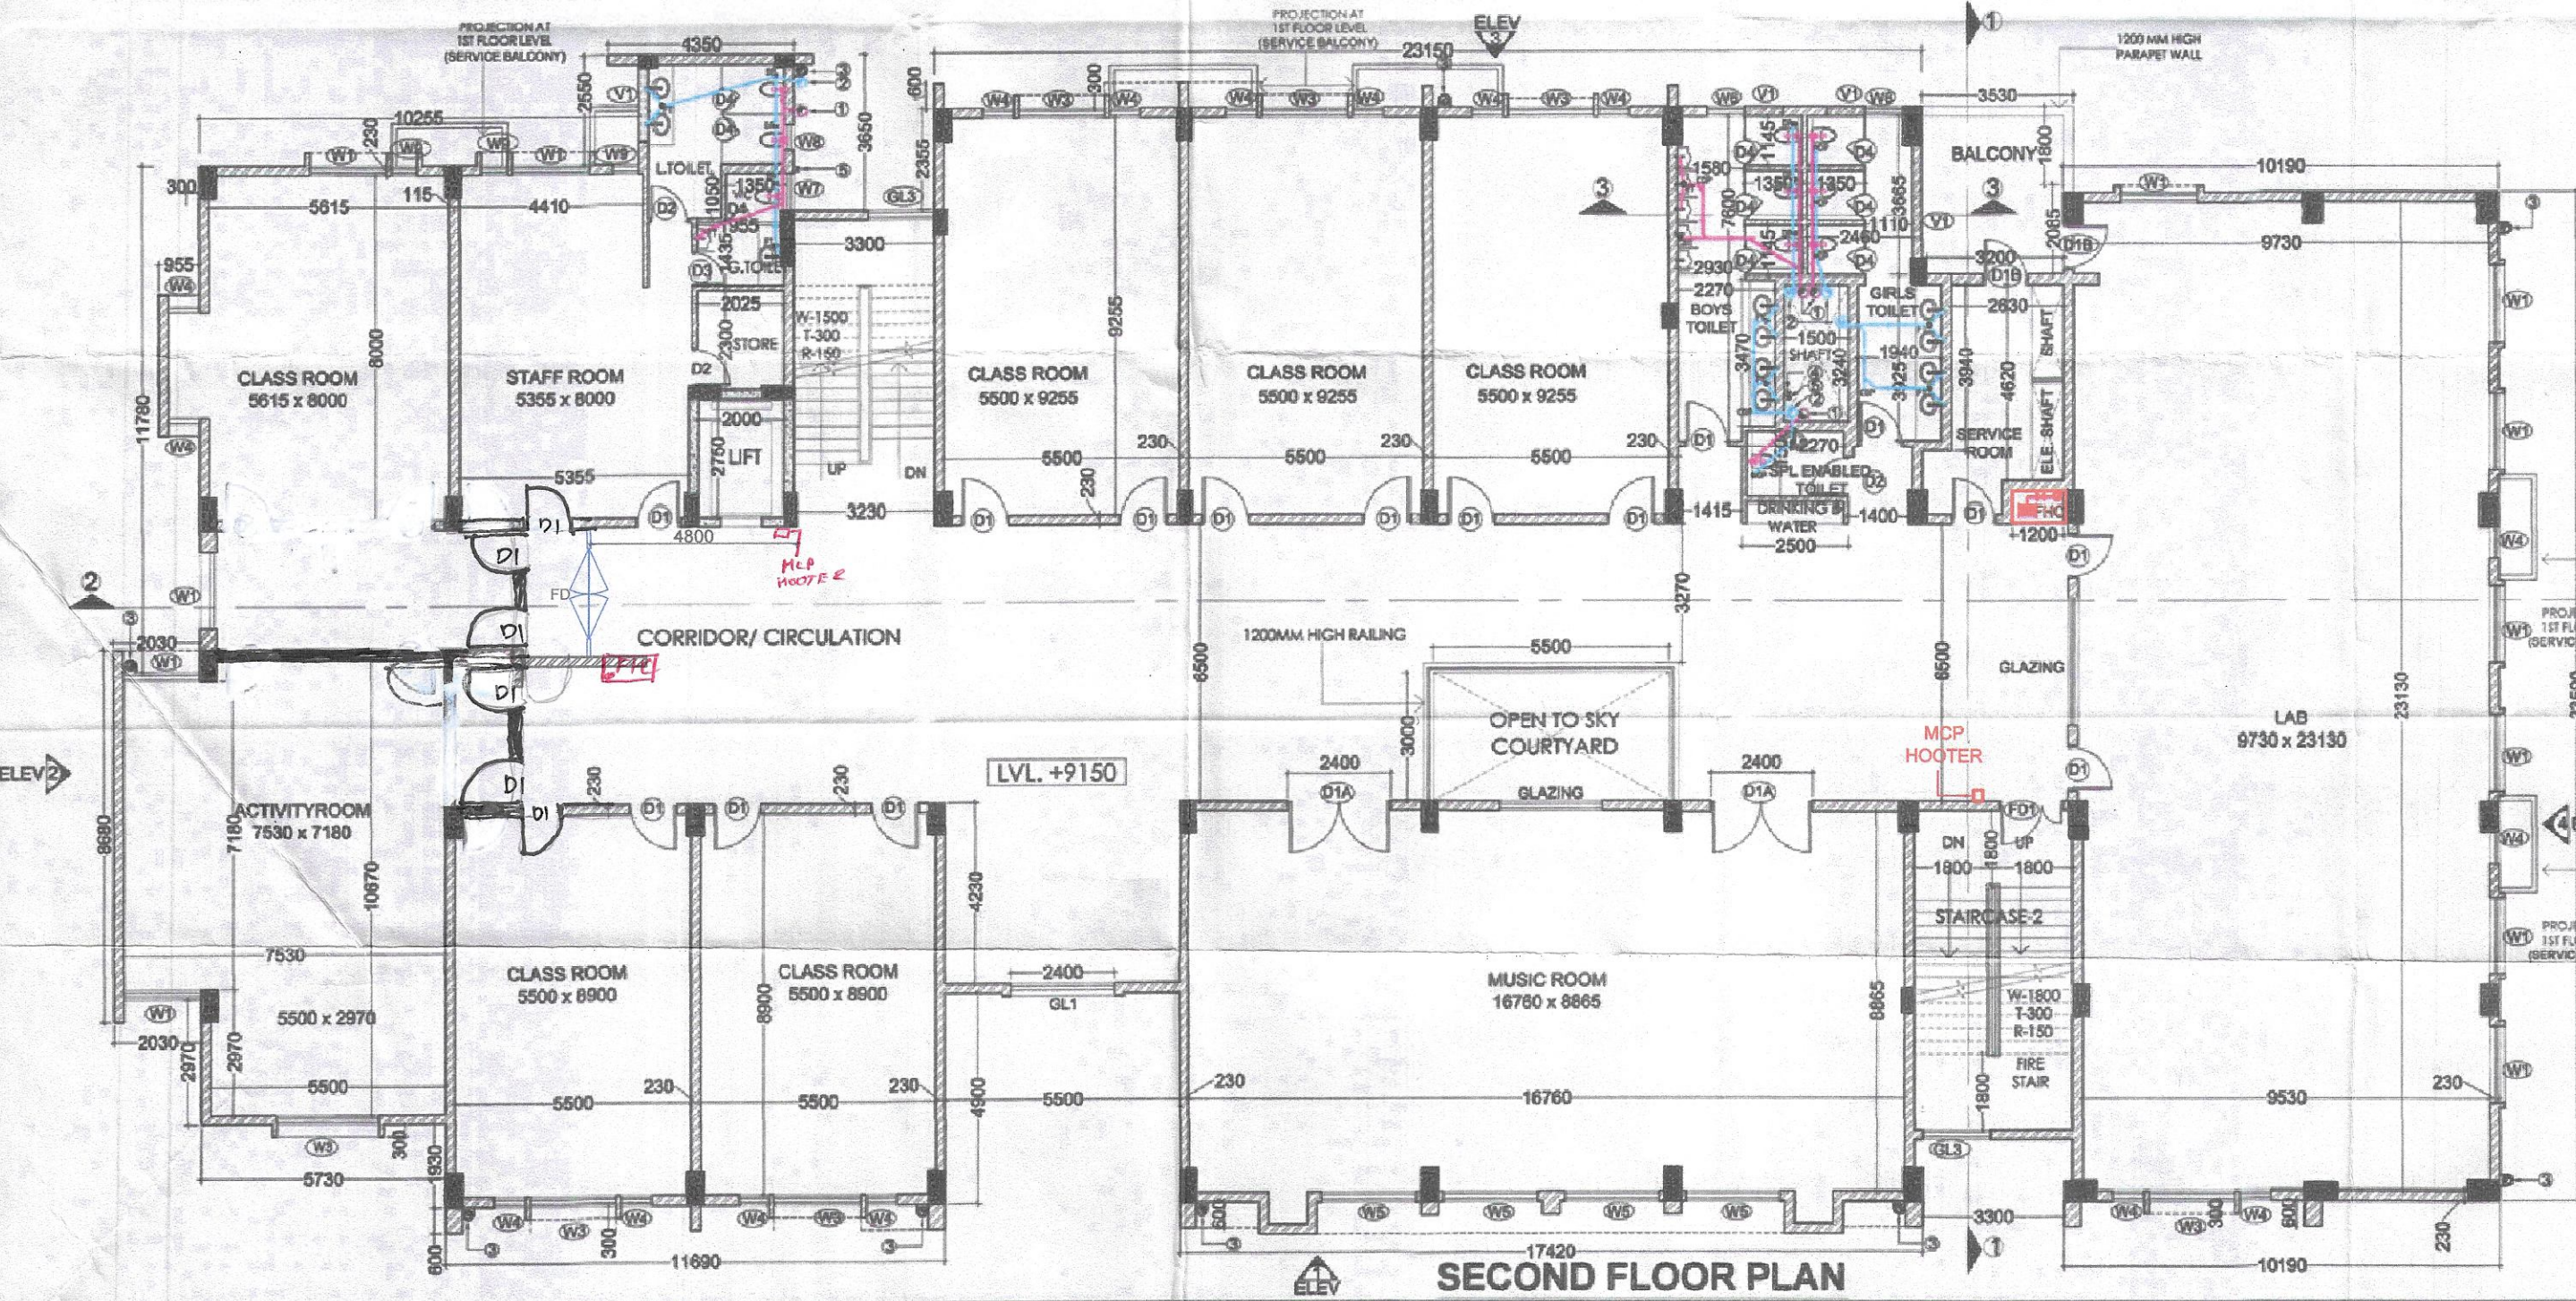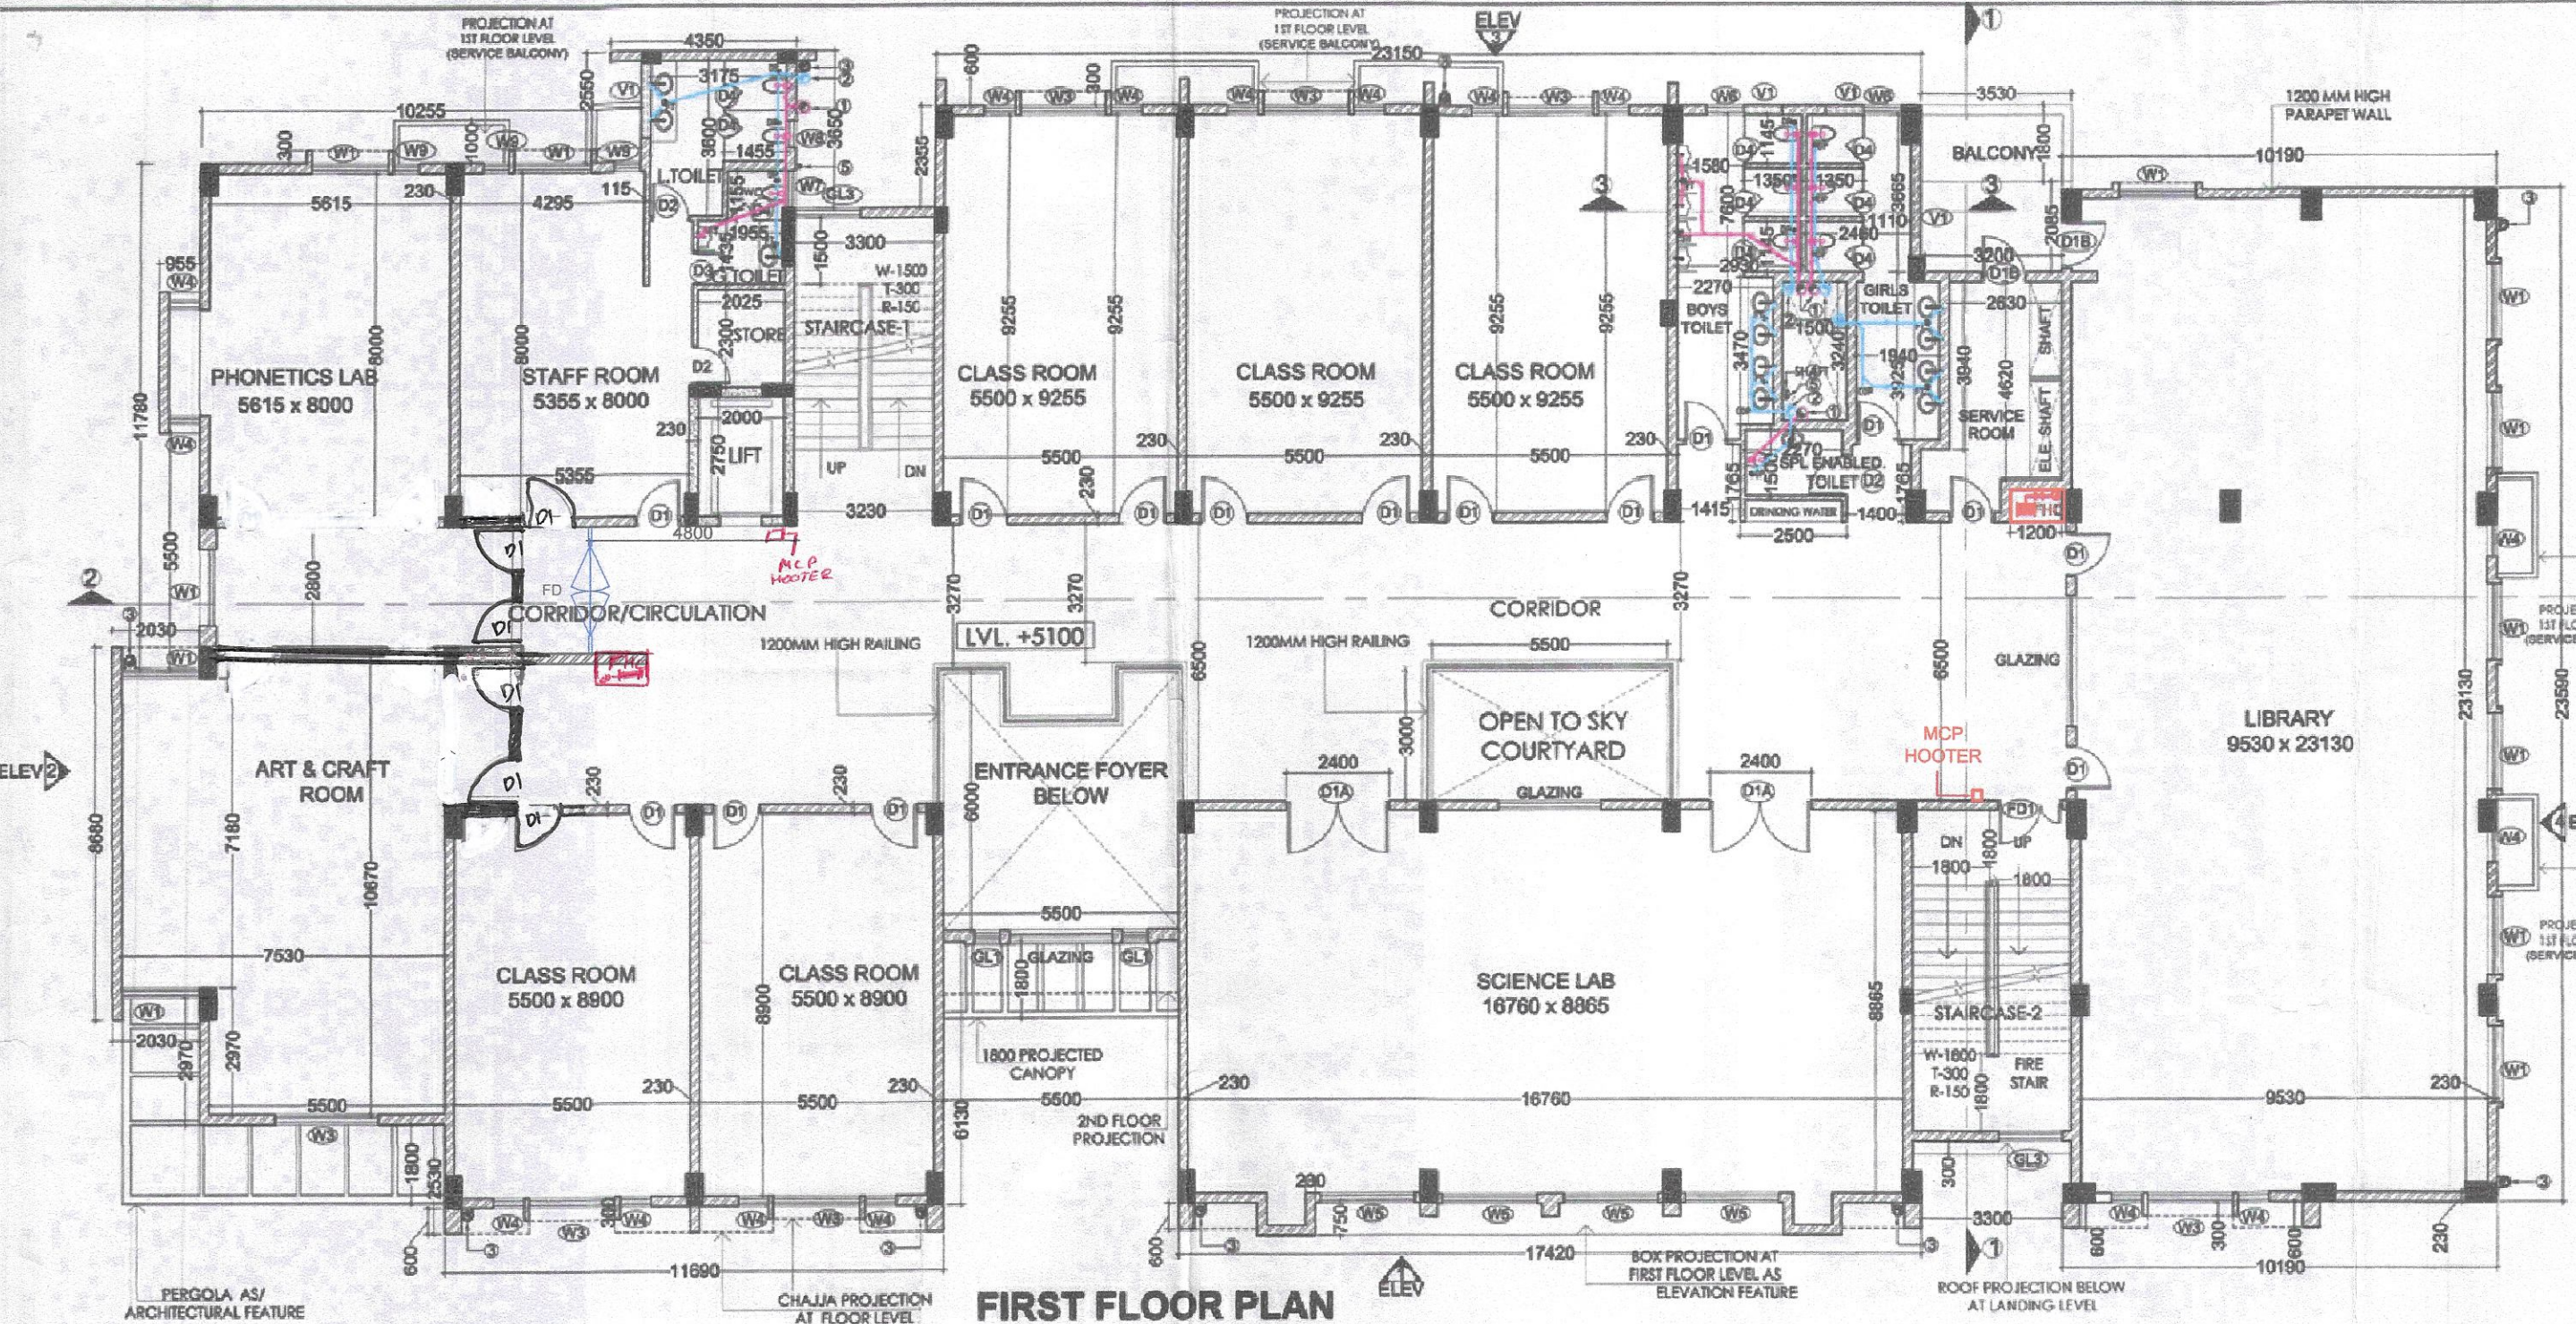

THIRD & TERRACE FLOOR PLAN

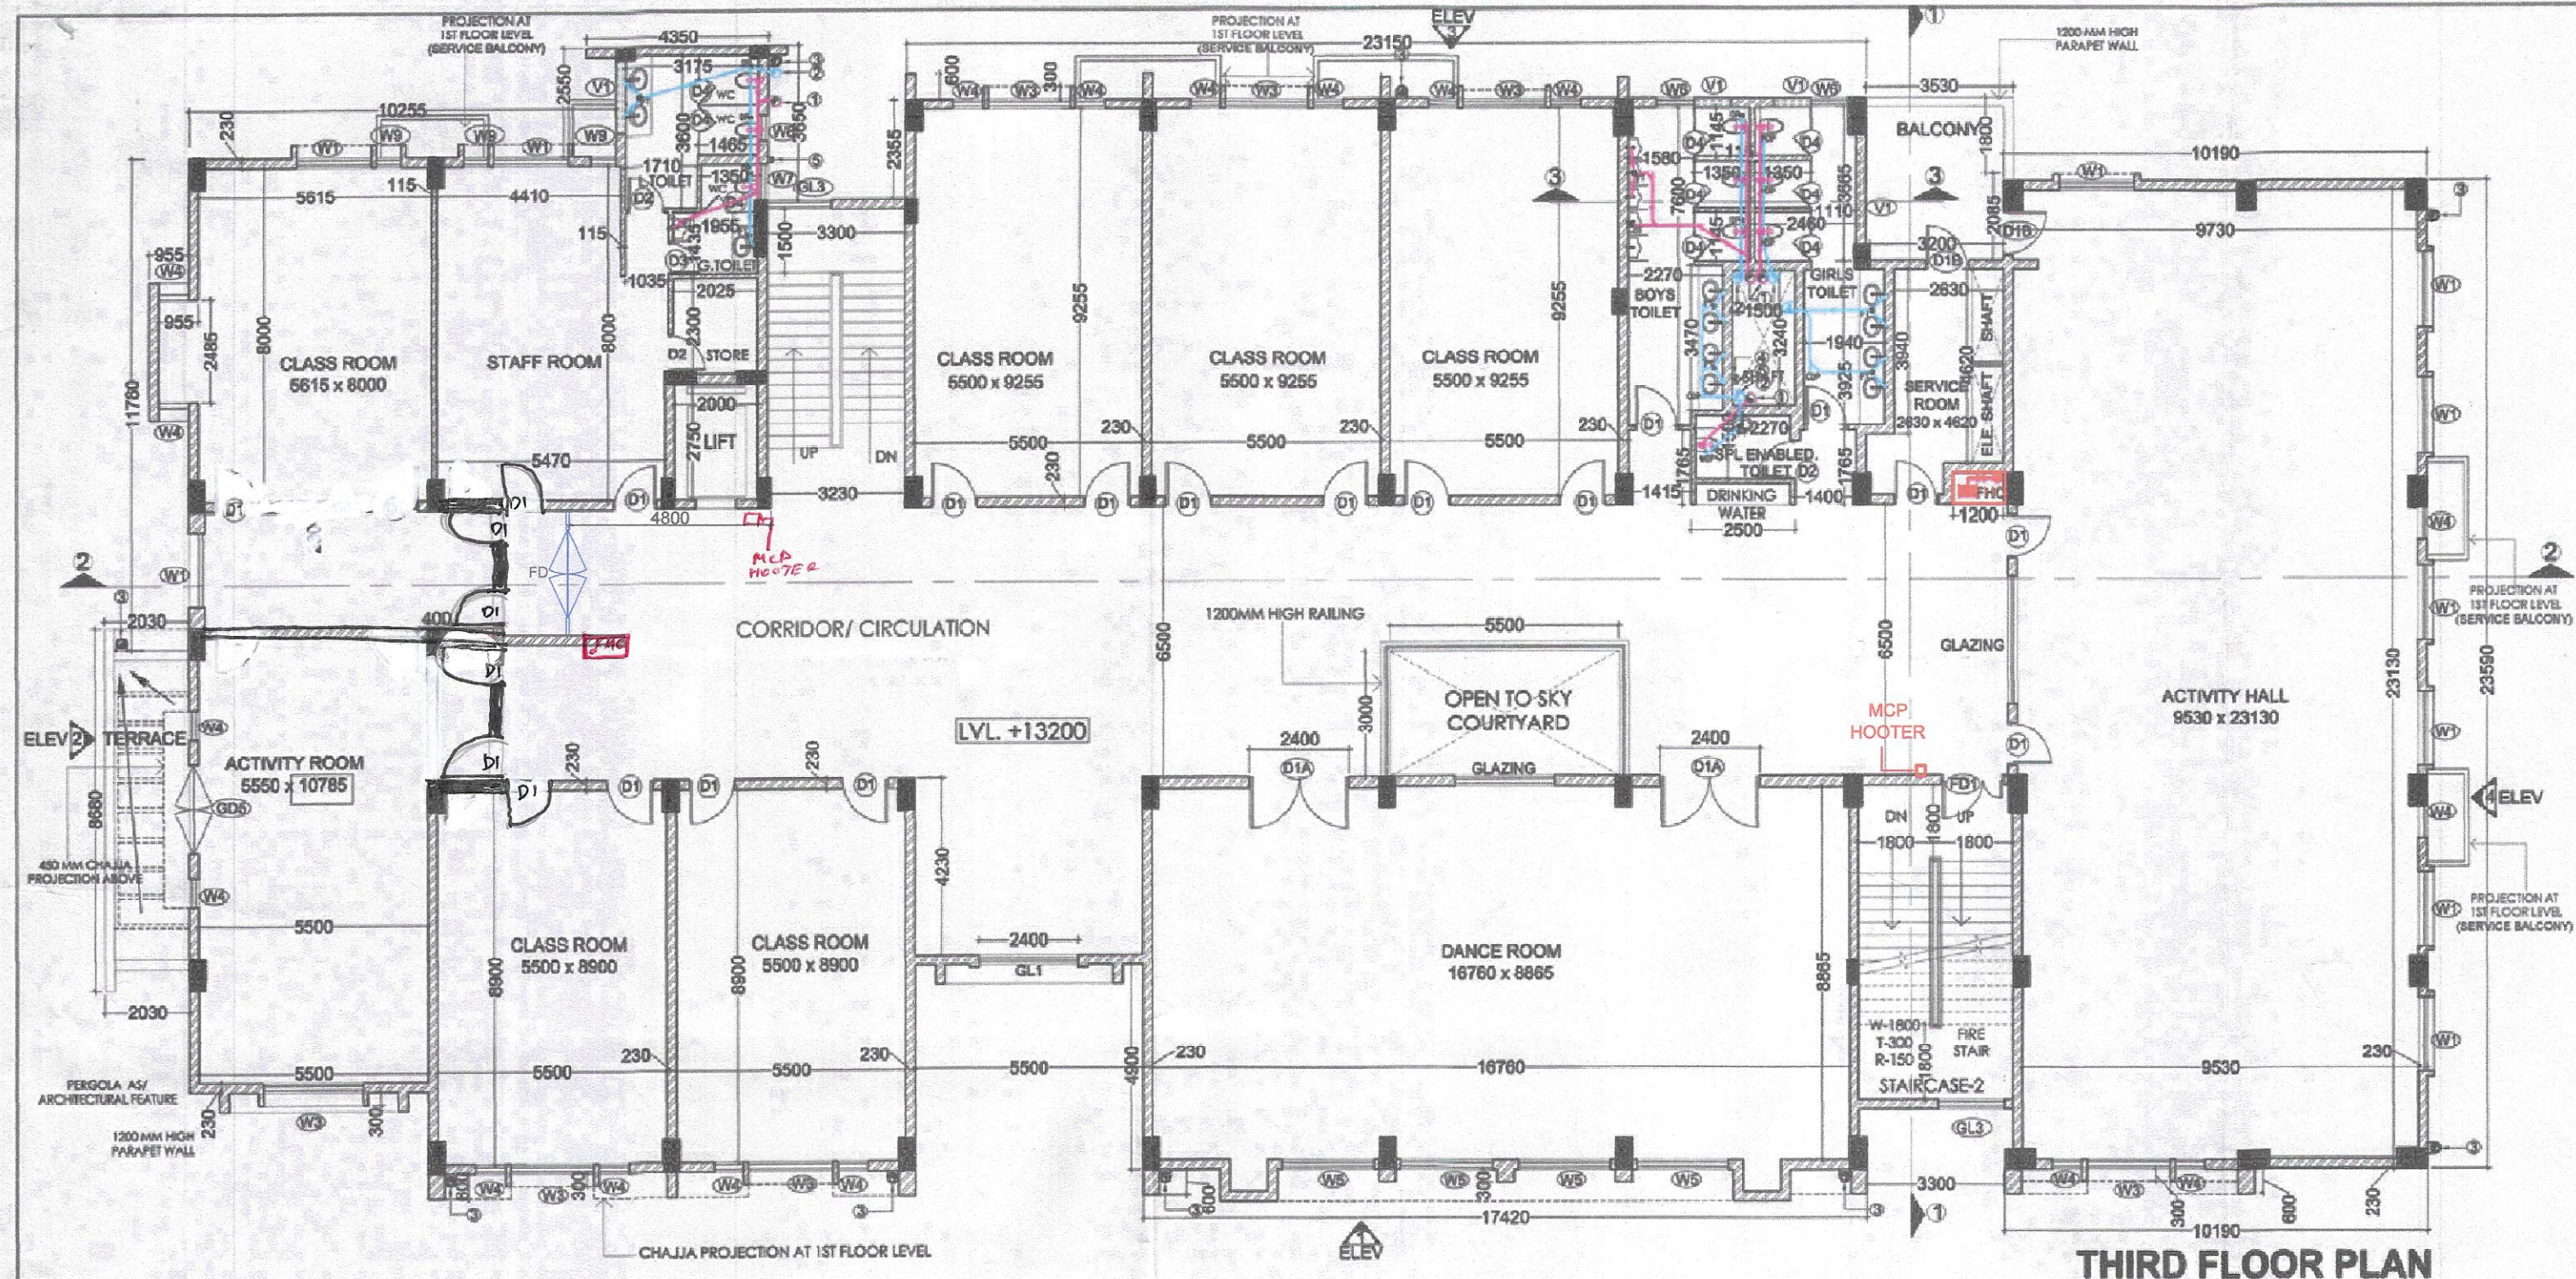

LEGEND

	WATER SUPPLY LINE
	SOIL PIPE LINE
	WASTE WATER PIPE
	STORM WATER DRAIN PIPE
	WATER SUPPLY TO FHC
	WATER SUPPLY TO SPRINKLER
	SEWERAGE MANHOLE
	GULLY TRAP
	INSPECTION CHAMBER
	DRAINAGE MANHOLE
	CATCH BASIN
	FLOOR TRAP
	DRAIN POINT

PIPE SCHEDULE

PIPE NO.	CLASSIFICATION	SIZE (Ø)
1	SOIL AND VENT PIPE	150/100
2	WASTE AND VENT PIPE	100
3	RAIN WATER PIPE	150
4	CWS RISER TO OHT	32
5	CWS DROP FROM OHT	32/20
6	FIRE PIPE DROP TO FHC	50
7	FIRE SPRINKLER PIPE DROP	100

S.NO.	TYPE	OPENING SIZE	CLL	INTEL	REMARKS
1	GD1	4000 X 3450	-	B.O.B	glazing door (2400mm)
2	GD2	2400 X 3450	-	B.O.B	glazing door (2400mm)
3	GD3	3000 X 3450	-	B.O.B	glazing door (2400mm)
4	GL	GLAZING	-	-	facade glazing
5	GL1	AS/FACADE	-	-	store glass
6	GL2	1500 X 1800	-	-	store glass
7	GL3	1500 X 2100	-	-	store glass
8	D1	1550 X 2750	-	2400	store glass
9	D1A	2400 X 2750	-	2750	store glass
10	D1B	1050 X 2750	-	2750	store glass
11	D2	800 X 2100	-	2100	store glass
12	D3	750 X 2100	-	2100	store glass
13	D4	600 X 2100	-	2100	store glass
14	D5	1500 X 2100	-	2100	store glass
15	FD1	1800 X 2100	-	2100	store glass
16	W1	1800 X 1850	900	2750	store glass
17	W2	1800 X 2450	900	B.O.B	store glass
18	W3	2000 X 1850	900	2750	store glass
19	W4	755 X 1850	900	2750	store glass
20	W5	2210 X 2350	900	2750	store glass
21	W6	800 X 1550	1200	2750	store glass
22	W7	870 X 1250	1500	2750	store glass
23	W8	800 X 1250	1800	2750	store glass
24	W9	650 X 1850	900	2750	store glass
25	V1	1800X900	-	B.O.B	store glass
26	V2	800X850	-	B.O.B	store glass
27	V3	500 HT	-	B.O.B	BASEMENT VENT

B.O.B BOTTOM OF BEAM

NOTE

- All levels are given in reference to ground level, assuming it to be 100.
- All dimensions are in mm unless otherwise specified.
- Drawings are to be scaled, within dimensions to be followed.
- Water supply system shall be provided as per prevailing norms of the Government.
- Sanitary system shall be provided as per prevailing norms of the Government.
- Proposed building shall be fully air conditioned and mechanically ventilated with 100% fresh air intake.
- Soil and water heating system will be provided as per norms.

PROJECT TITLE

REVISED BUILDING PLAN OF PRIMARY SCHOOL SITE (PS-3) MEASURING 1.00 ACRE FALLING IN RESIDENTIAL PLOTTED COLONY MEASURING 365.396 ACRES (LICENCE NO.1134 TO 1166 OF 2006 DATED 22.09.2006, LICENCE NO.187 OF 2008 DATED 08.11.2008 AND LICENCE NO.17 OF 2009 DATED 31.5.2009) IN SECTOR 34 (PART) 35 & 36, ROHTAK BEING DEVELOPED BY SHARAD FARMS AND HOLDINGS PVT. LTD. AND OTHERS.

LOCATION SECTOR 35, ROHTAK, HARYANA

FIRE DRAWING

DRAWING TITLE FLOOR PLANS

DRAWING NO.

DATE: FEB 2017 SCALE: 1:100

CHECKED:

S.T.P. S.E. HUDA D.T.P. ROHTAK (Chairman) (Member) (Member) For Sharad Farms & Holdings Pvt. Ltd.



ARCHITECTS & PLANNERS

wrtA Design Studio

Rohita (LLP) e mail: wrtadestudios@gmail.com


Ranjan Mohanty CA/2002/30498

Ranjan Kumar Mohanty Architect CA/2002/30498

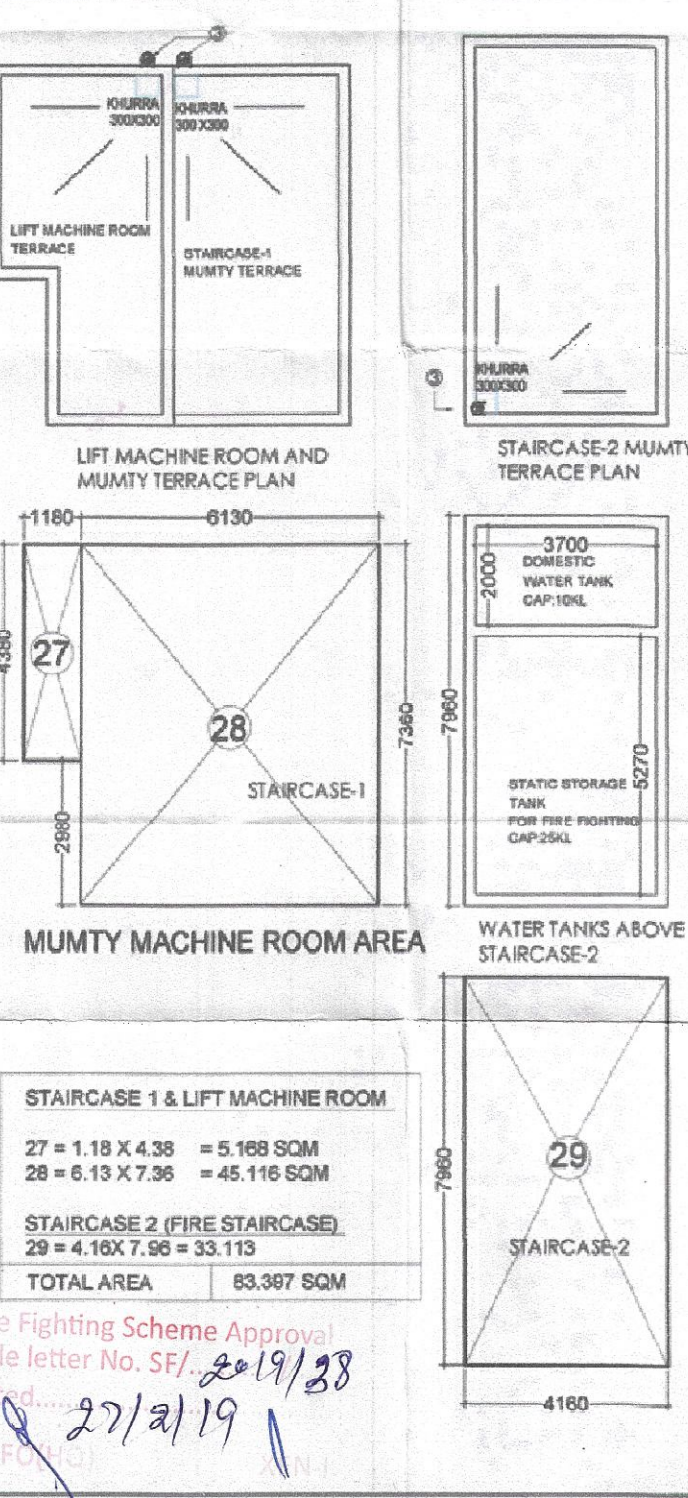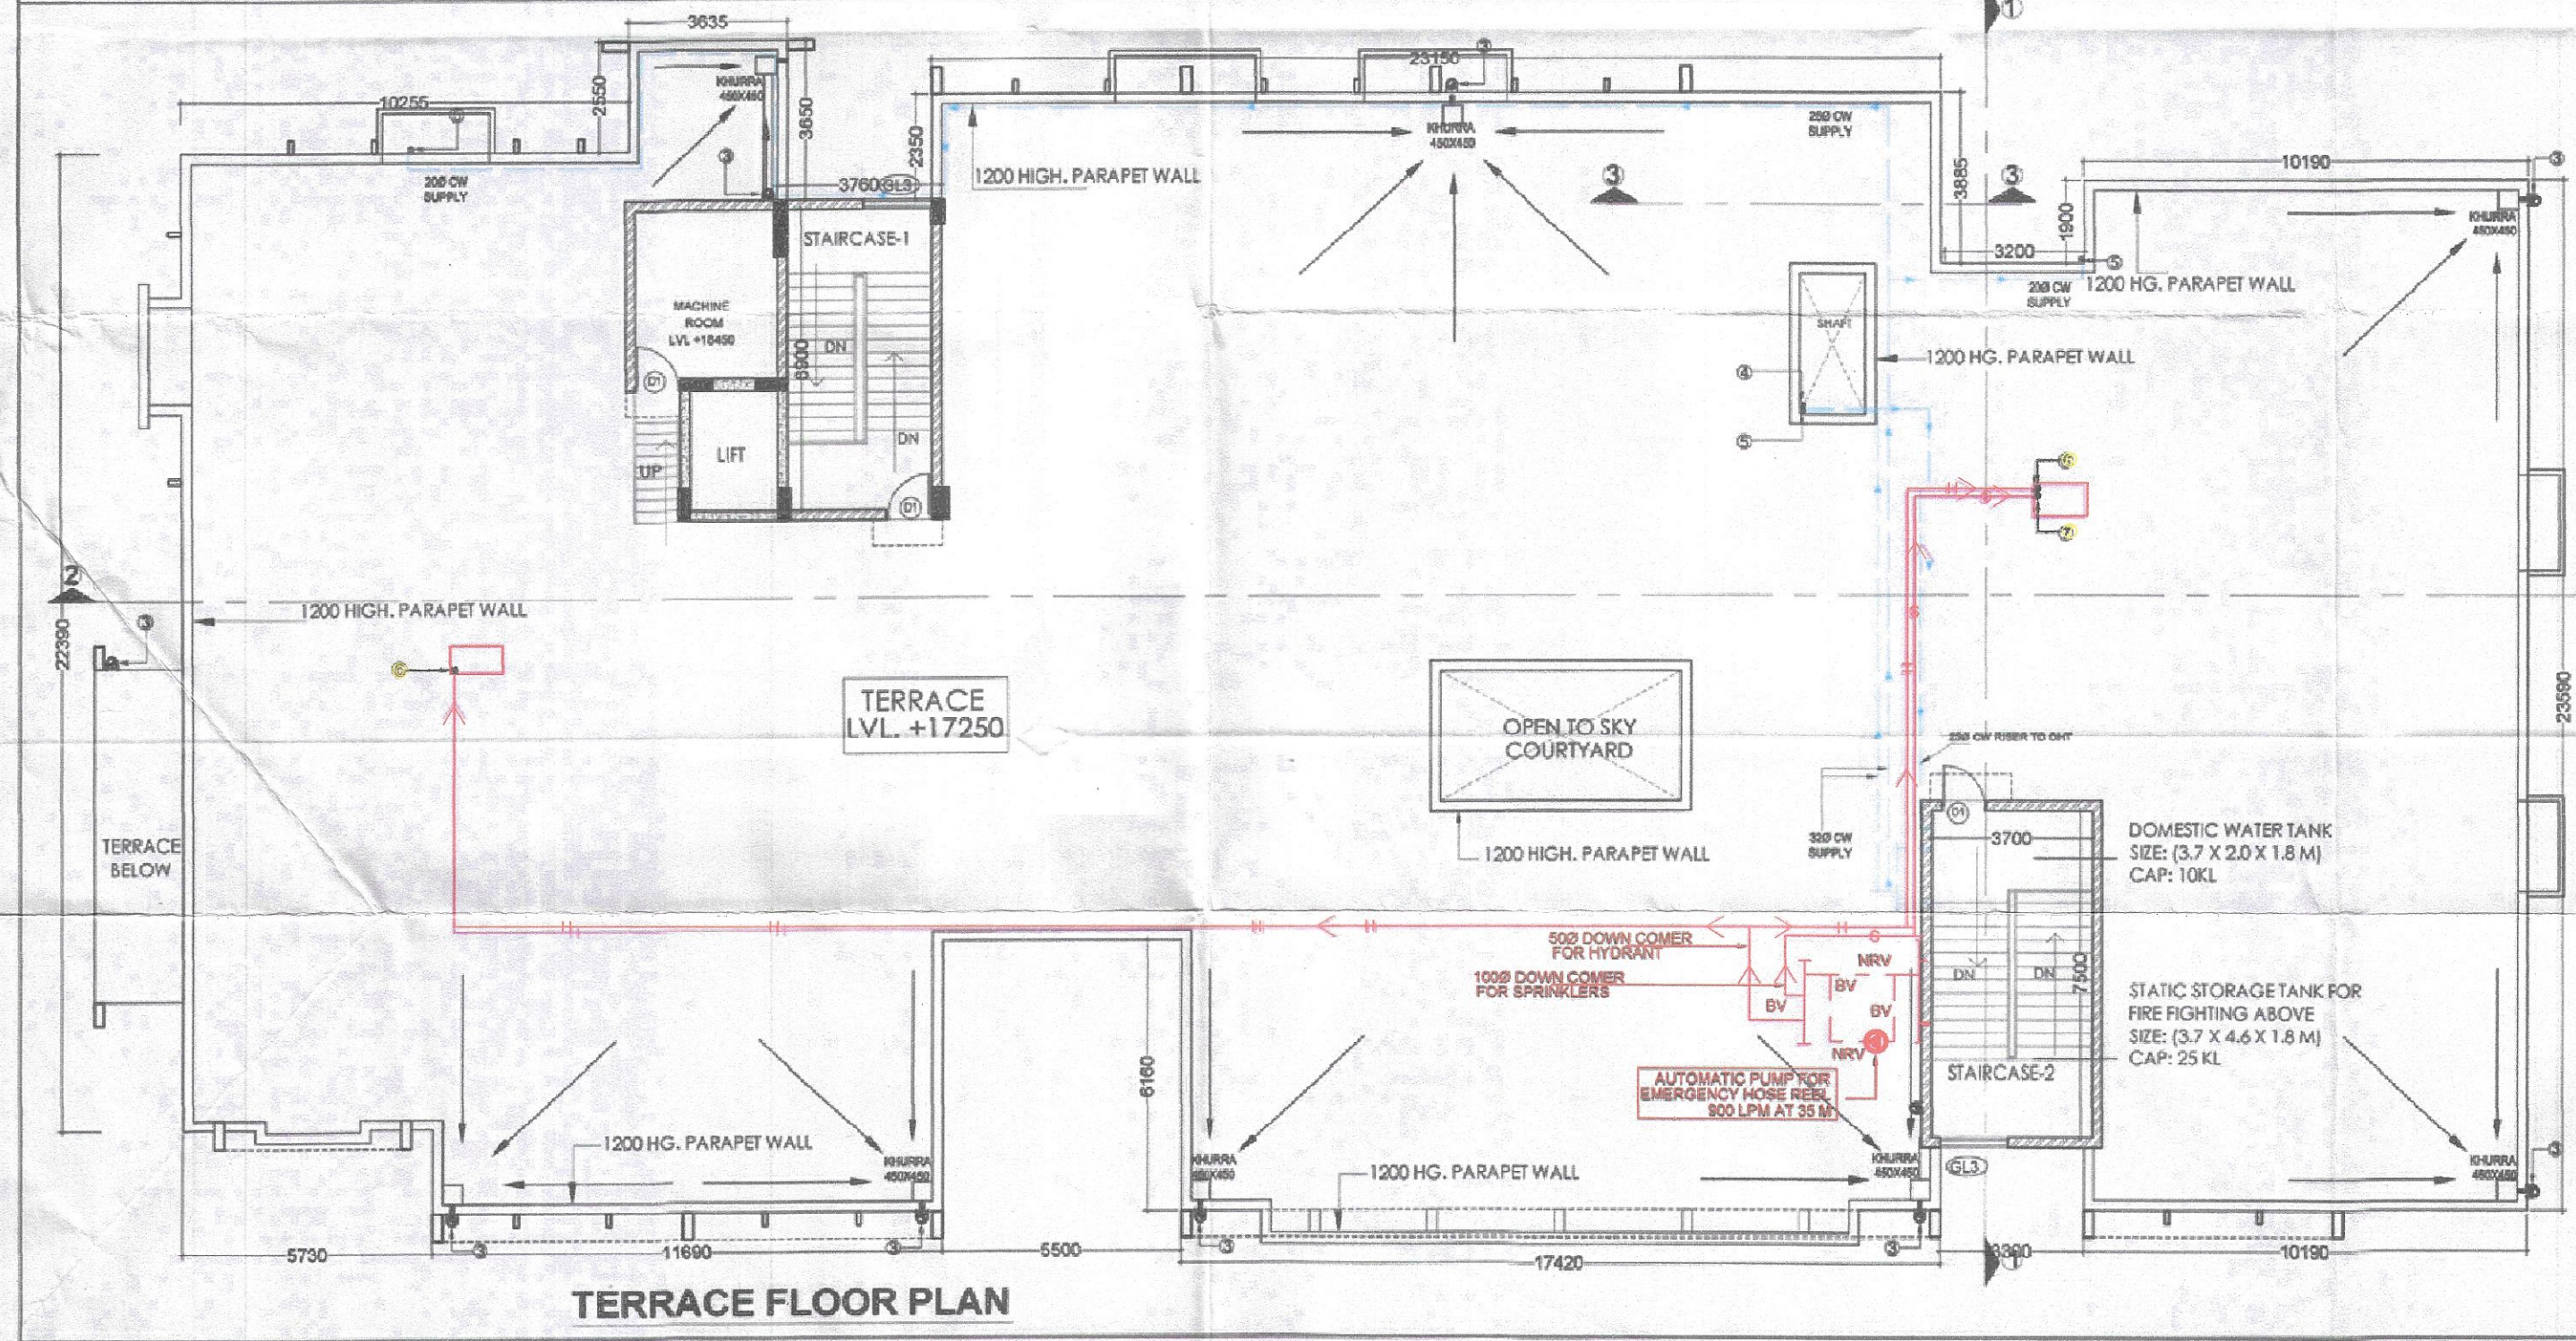


STAIRCASE 1 & LIFT MACHINE ROOM
27 = 1.18 X 4.38 = 5.168 SQM
28 = 6.13 X 7.36 = 45.116 SQM
STAIRCASE 2 (FIRE STAIRCASE)
29 = 4.16 X 7.96 = 33.113
TOTAL AREA 83.397 SQM


Fire Fighting Scheme Approval
Vide letter No. SF/2019/38
Dated 27/2/19
ADFC

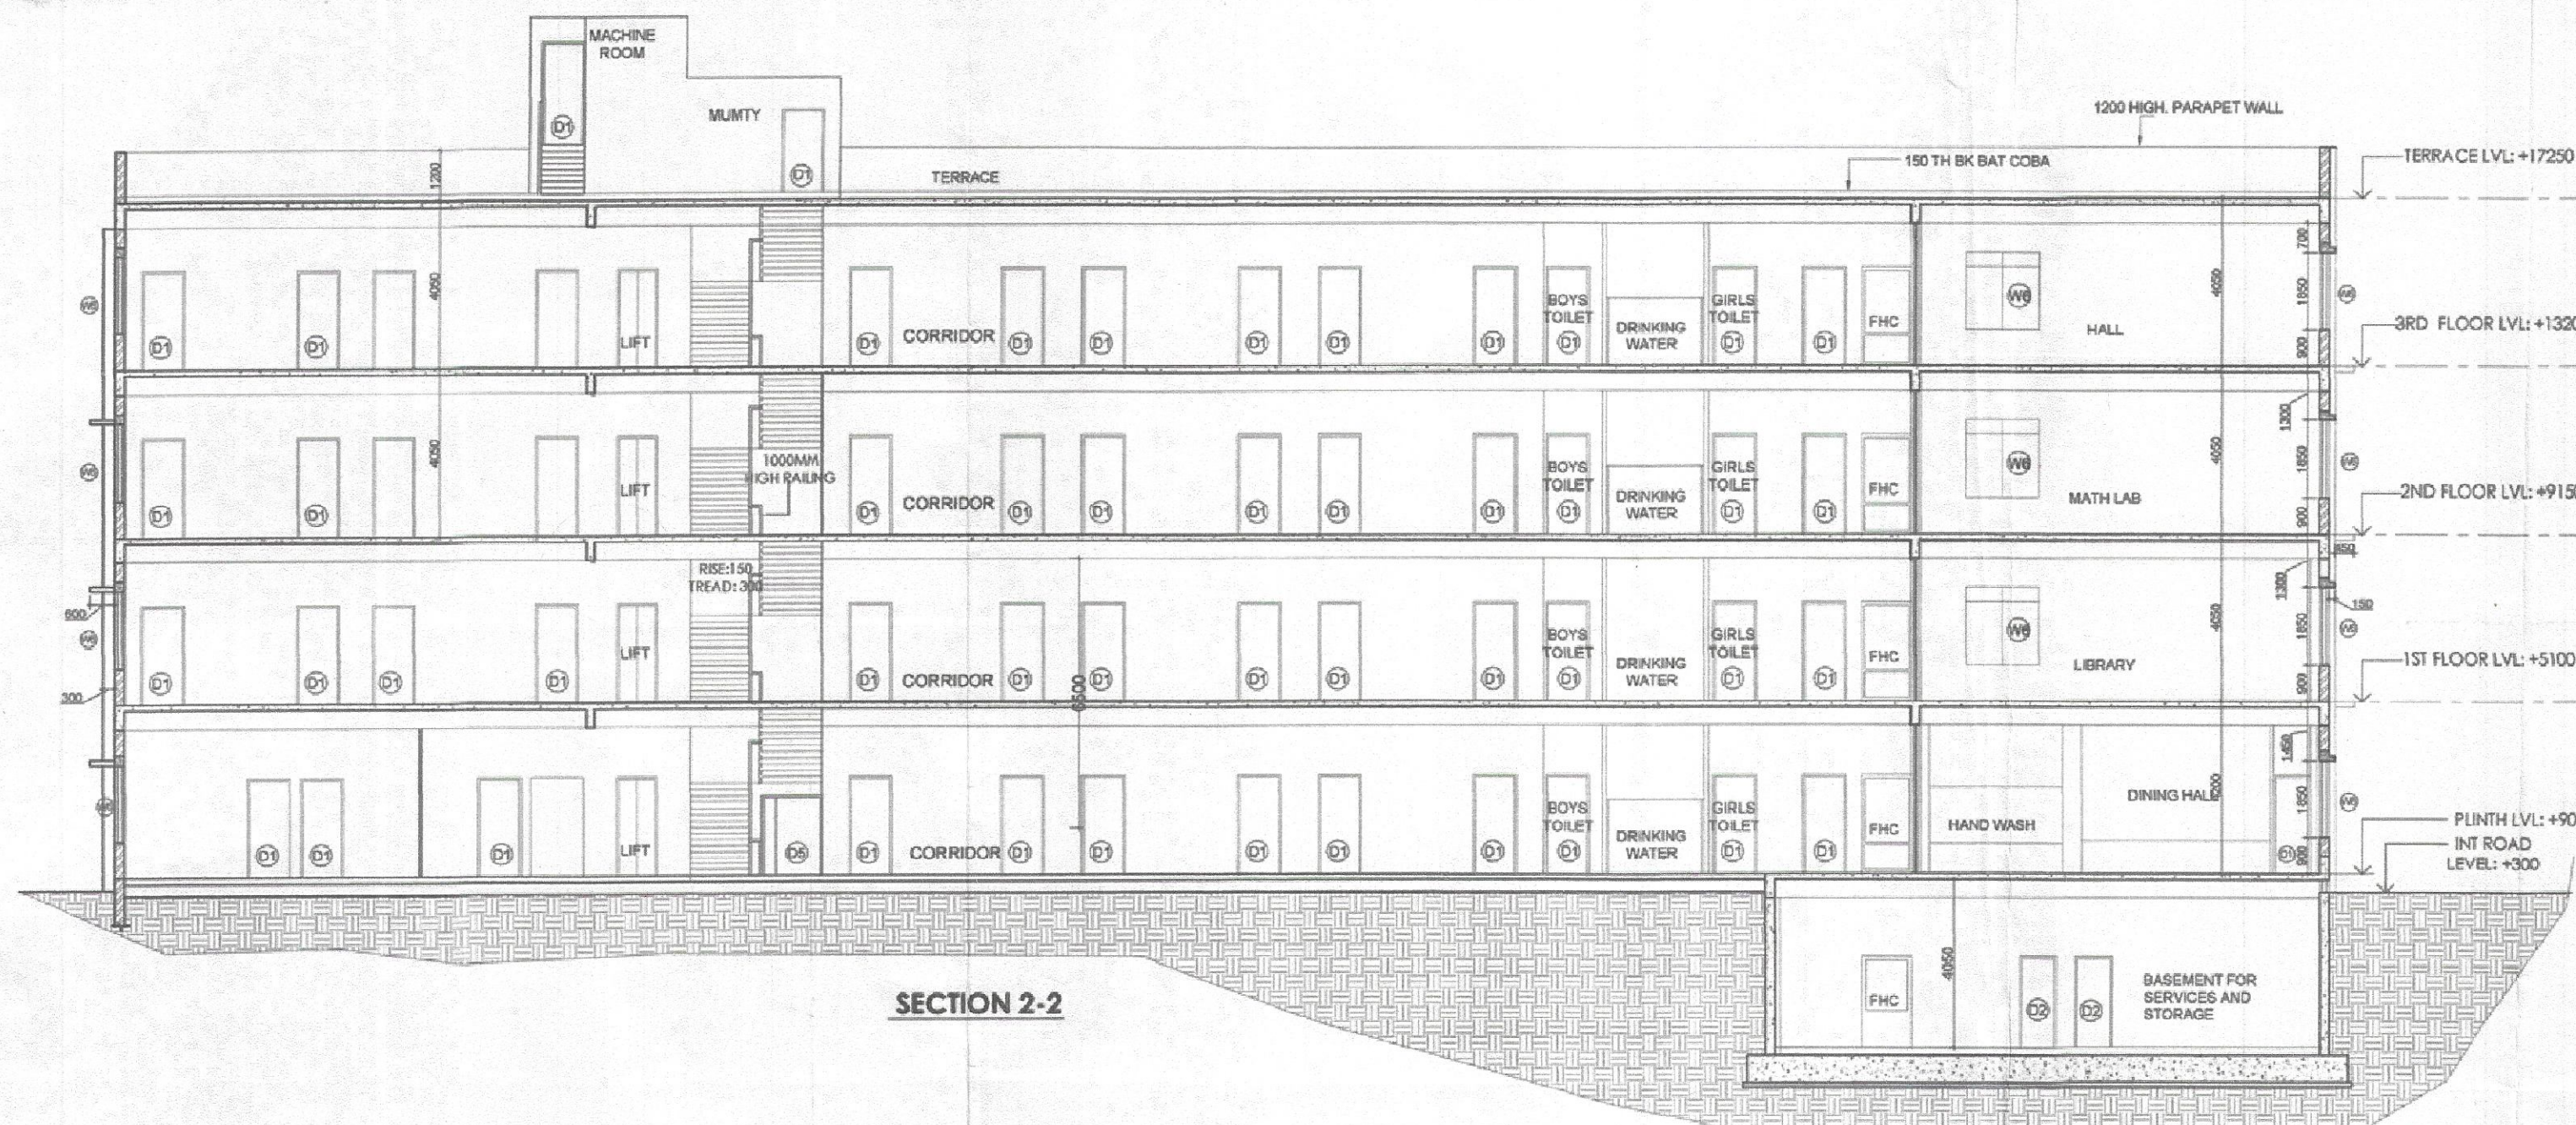

SECTION 2-2

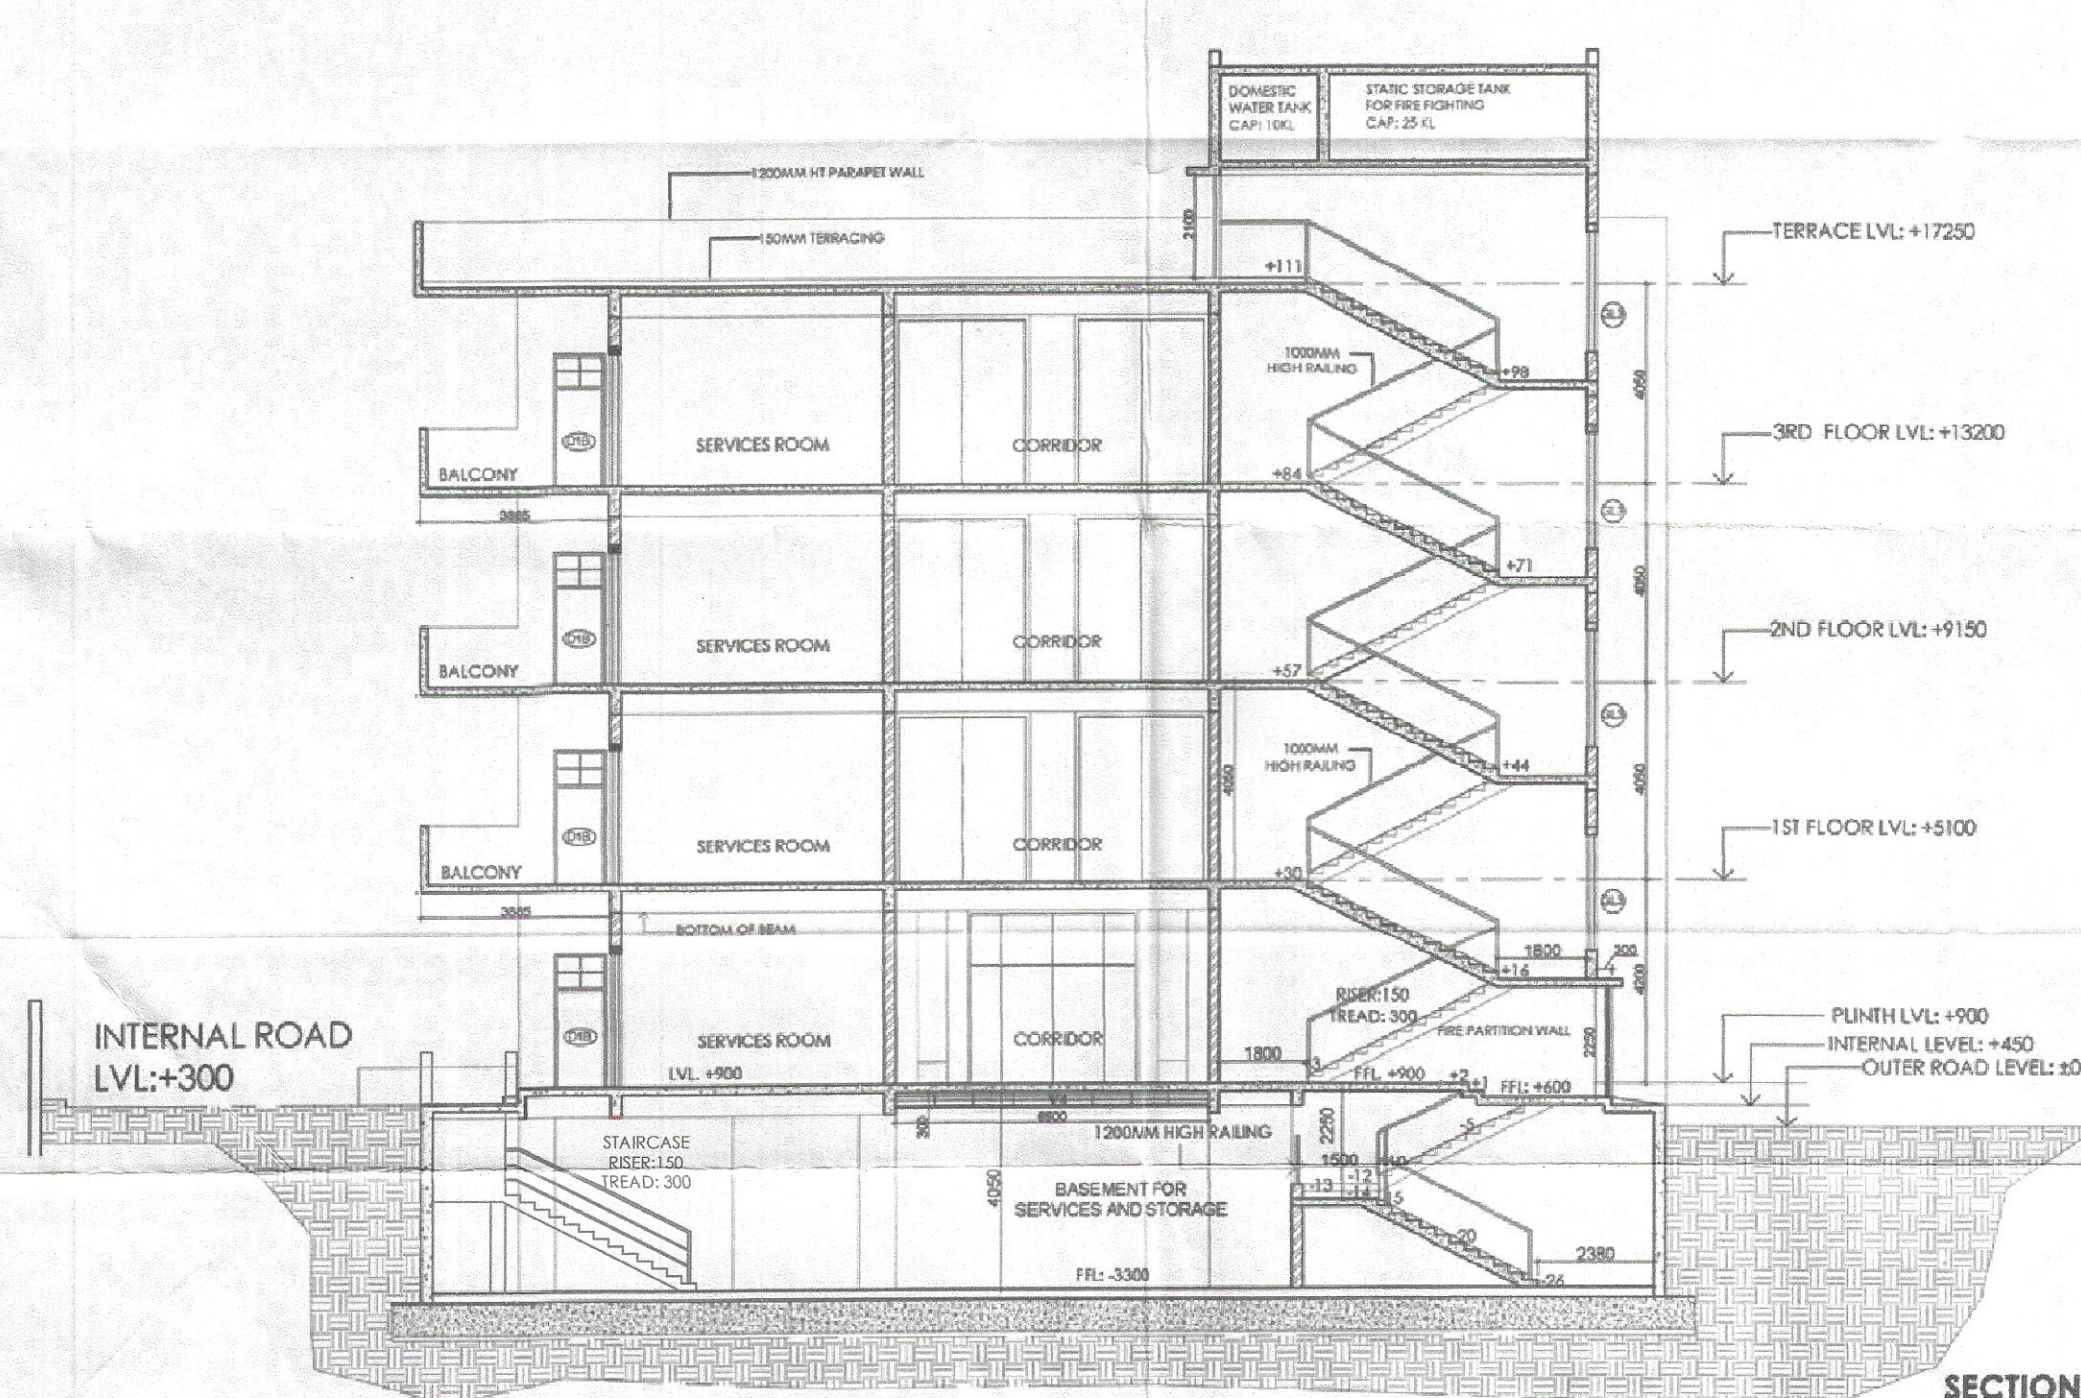

SECTION 1-1

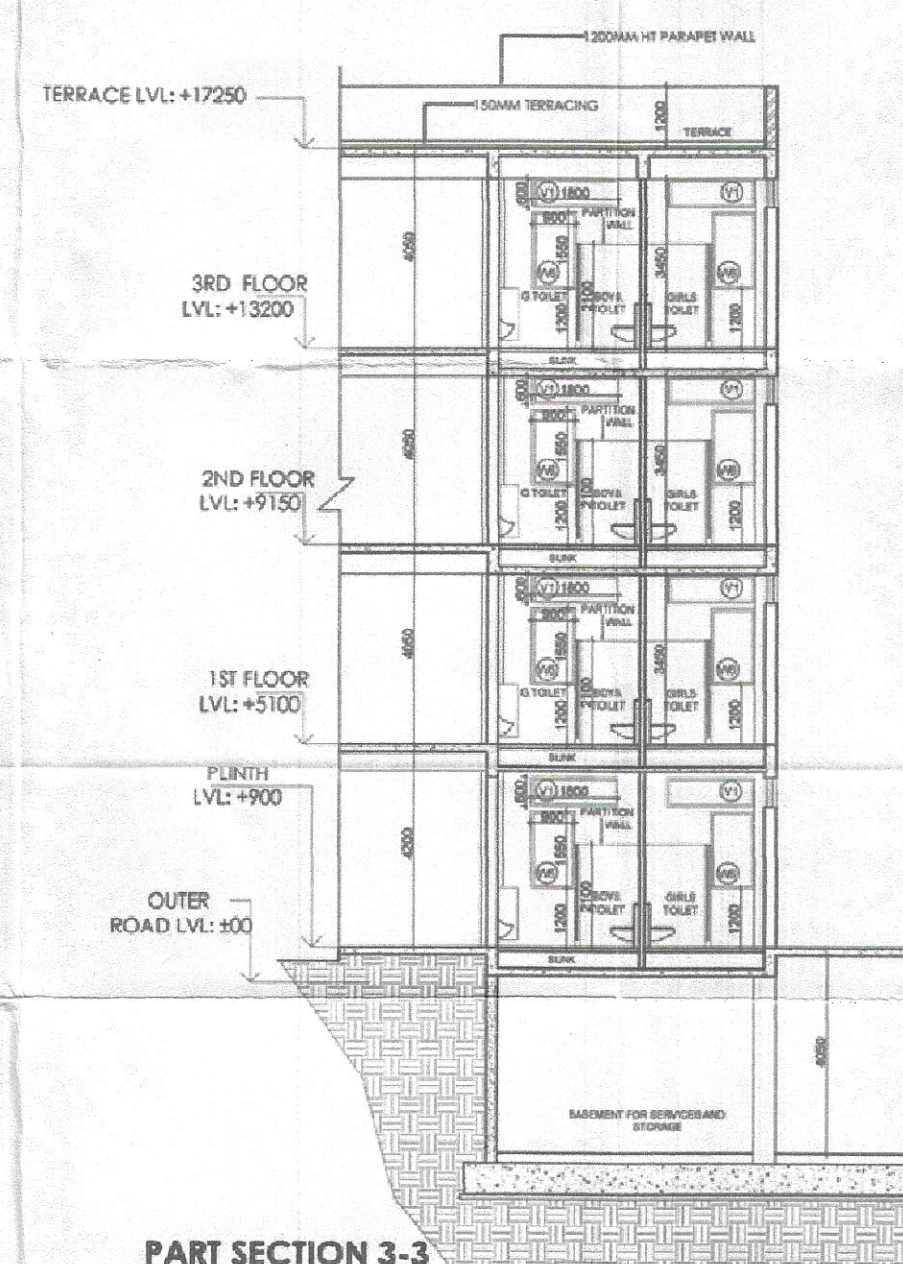

PART SECTION 3-3

SUBMISSION DRAWING-07

SECTIONS

S.P. Roshan
 S.E. Ruda
 D.T.P. Bhargava
 (Chairman) (Member) (Member)

Issued vide SFP (R) Memo No. 27/2/19

Fire Fighting Scheme Approval
 vide letter No. SF/ 27/2/19
 27/2/19

NOTE:
 1. All levels are given in reference to external road level, assuming it to be 400.
 2. All dimensions are in millimeters unless otherwise specified.
 3. Drawings not to be scaled, within dimensions to be followed.
 4. Rain water harvesting system shall be provided at site as per prevailing norms of the Government.
 5. LED system shall be provided at site as per prevailing norms of the Government.
 6. Replace building shall be fully air conditioned and mechanically ventilated with 100% fresh air.
 7. Solar distilled water heating system will be provided as per norms.

PROJECT TITLE
 REVISED BUILDING PLAN OF PRIMARY SCHOOL SITE (PS-3) MEASURING 1.00 ACRE FALLING IN RESIDENTIAL PLOTTED COLONY MEASURING 365.396 ACRES LICENCE NO. 1134 TO 1166 OF 2006 DATED 22.09.2006, LICENCE NO. 187 OF 2008 DATED 08.11.2008 AND LICENCE NO. 17 OF 2009 DATED 31.5.2009 IN SECTOR 34 (PART) 35 & 36, ROHTAK BEING DEVELOPED BY SHARAD FARMS AND HOLDINGS PVT. LTD. AND OTHERS.

GARGI FARMS

LOCATION SECTOR 35, ROHTAK, HARYANA

FIRE DRAWING

DRAWING TITLE BUILDING SECTIONS

DRAWING NO.

DATE: FEB 2017 SCALE: 1:100

DRAWN:

CHECKED:

OWNER

Per Sharad Farms & Holdings Pvt. Ltd.

Auth: Sign./Director

ARCHITECTS & PLANNERS

wrtA Design Studio
 Noida (U.P.)
 e-mail: wrtadesigns@gmail.com

Ranjan Kumar Mohanty
 Architect
 CA/2002/30498